
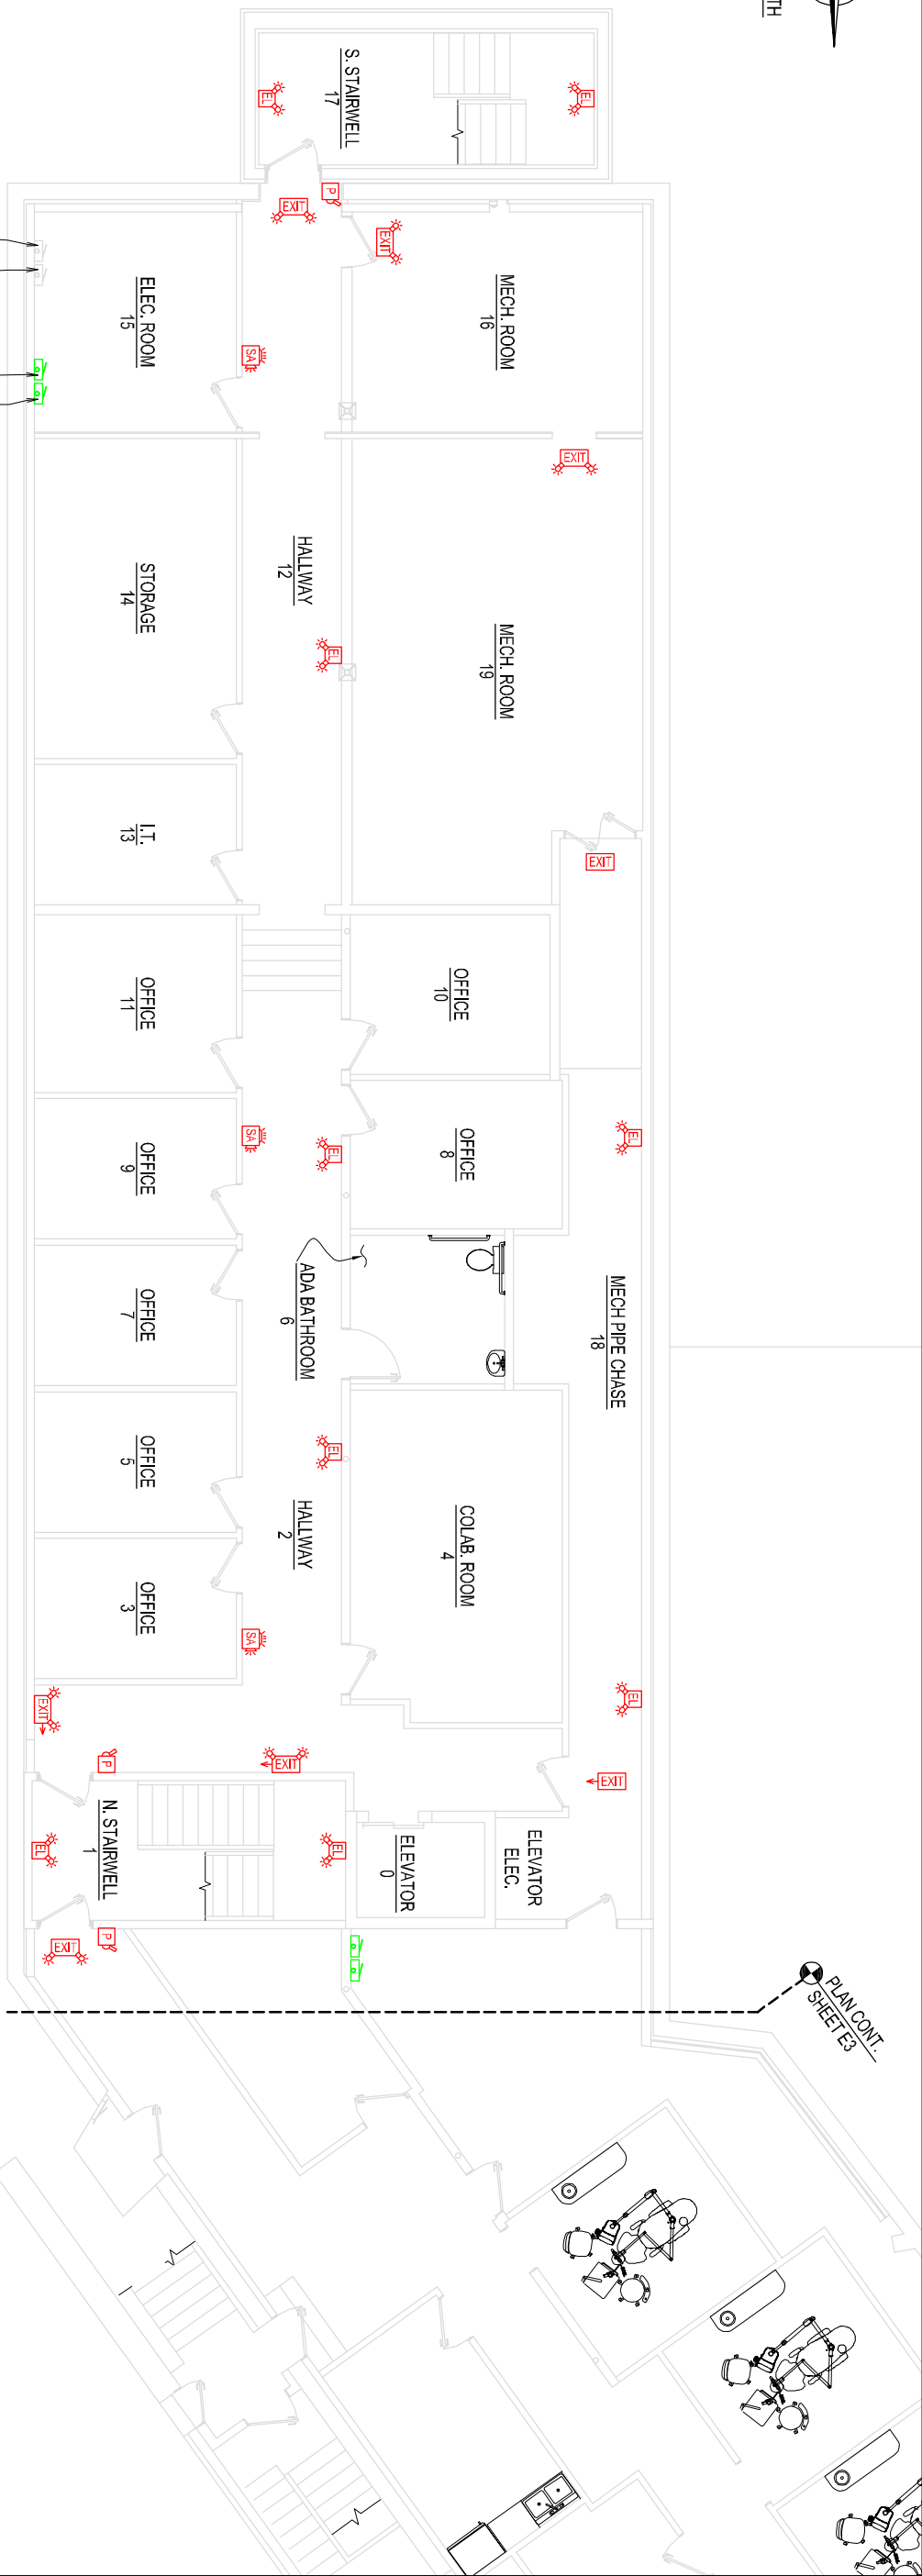


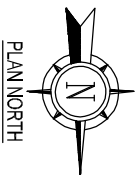

REUSED ELEC. PANEL PP000 SERVING HEALTH CENTER BASEMENT FLOOR (SEE SHEET ??????)


REUSED ELEC. PANEL LP000 SERVING HEALTH CENTER BASEMENT FLOOR (SEE SHEET ??????)

ELEC. PANEL LP-100 SERVING HEALTH CENTER 1ST FLOOR (SEE SHEET ??????)


ELEC. PANEL PP-100 SERVING HEALTH CENTER 1ST FLOOR (SEE SHEET ??????)

HEALTH CENTER BASEMENT LIFE SAFETY ELEC. FLOOR PLAN

SCALE: 3/32 IN. = 1 FT.

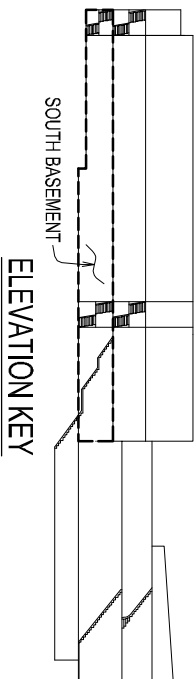

ELEVATION KEY

 


FORESIGHT ENGINEERING P.C.
10 FLEMING STREET
LINCOLN, MAINE 04457
(207) 794-2775
(PHONE OR FAX)

THIS DRAWING IS AN INSTRUMENT
DESIGNED TO FACILITATE THE WORK
UNDER THE JOB NUMBER INDICATED.
IT IS THE PROPERTY OF FORESIGHT
ENGINEERING AND IS NOT TO BE USED
FOR OTHER WORK ACCEPT BY
WRITTEN AGREEMENT WITH
FORESIGHT ENGINEERING.

HEALTH CENTER BASEMENT LIFE SAFETY ELEC. FLOOR PLAN
ST. CROIX HEALTH CENTER
MAIN STREET
CALAIS, MAINE

DATE: 9/21/26
SCALE: NOTED
DRAWN: MST
JOB NO: 26001E
REV 06
E2

NOT FOR CONSTRUCTION
FOR REVIEW ONLY

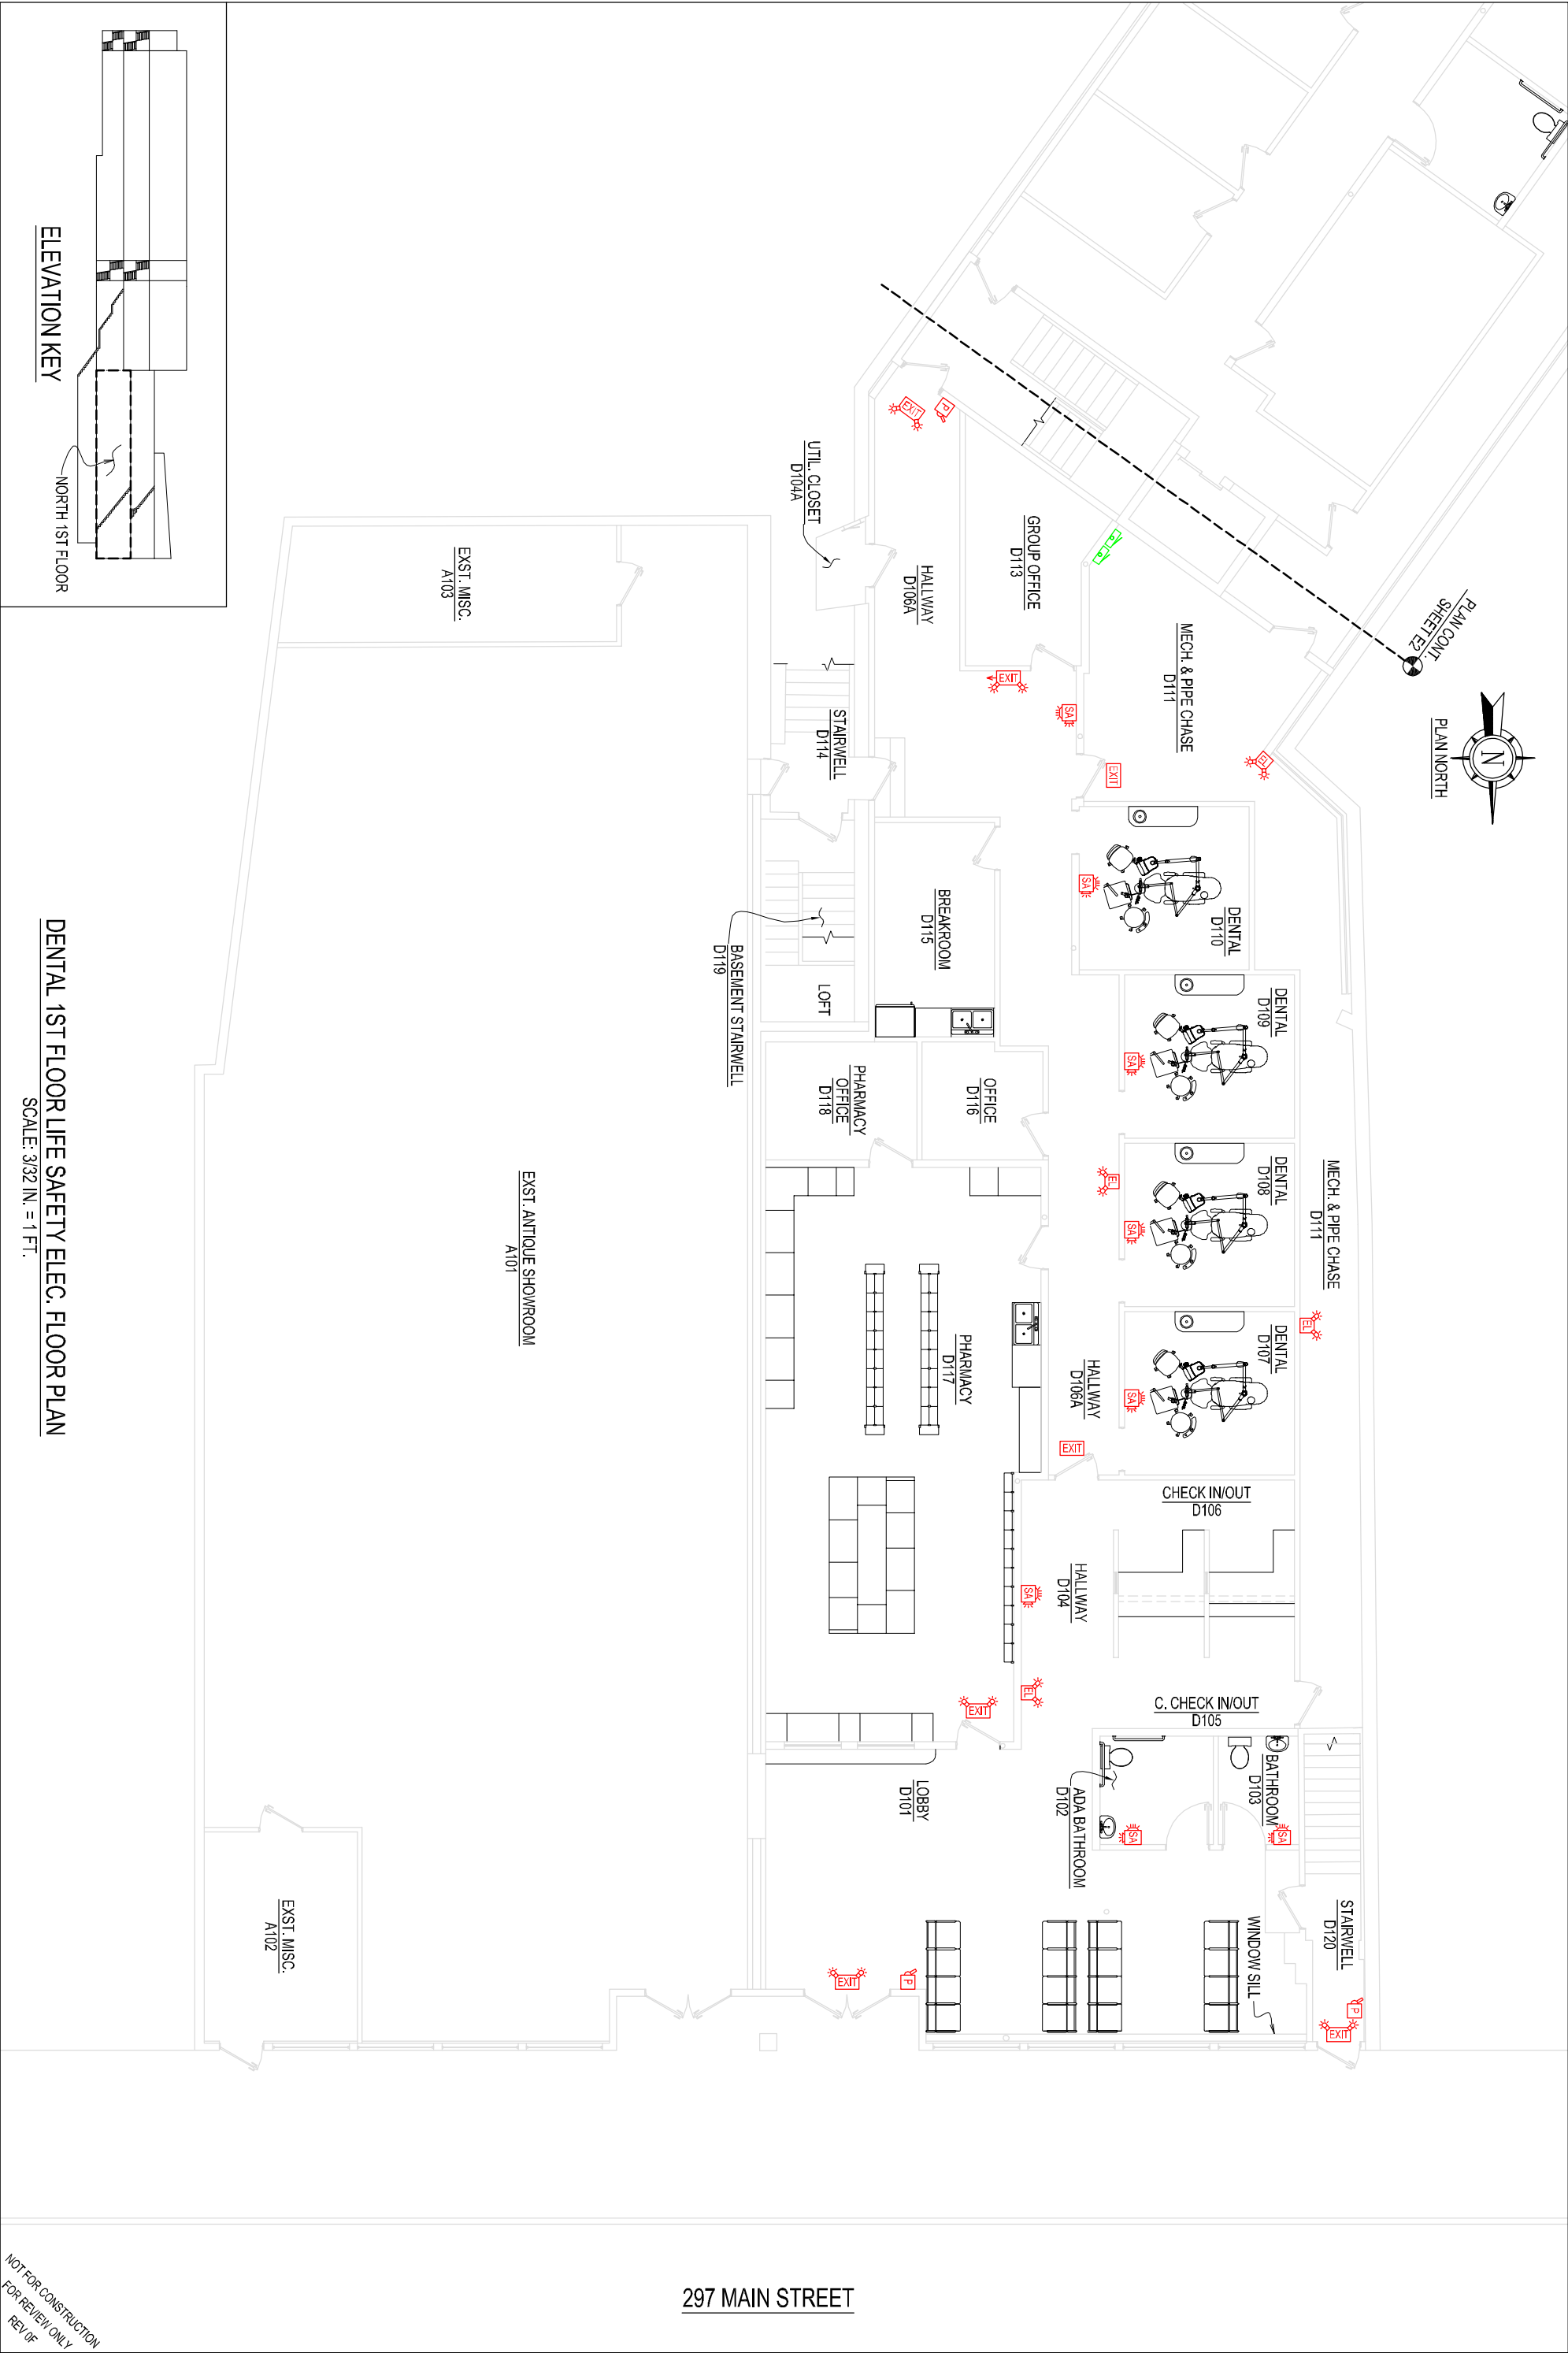


DENTAL 1ST FLOOR LIFE SAFETY ELEC. FLOOR PLAN



ST. CROIX HEALTH CENTER
MAIN STREET
CALAIS, MAINE

THIS DRAWING IS AN INSTRUMENT
DESIGNED TO FACILITATE THE WORK
UNDER THE JOB NUMBER INDICATED.
IT IS THE PROPERTY OF FORESIGHT
ENGINEERING AND IS NOT TO BE USED
FOR OTHER WORK ACCEPT BY
WRITTEN AGREEMENT WITH
FORESIGHT ENGINEERING.

FORESIGHT ENGINEERING P.C.

 10 FLEMING STREET
LINCOLN, MAINE 04457
(207) 794-2775
(PHONE OR FAX)



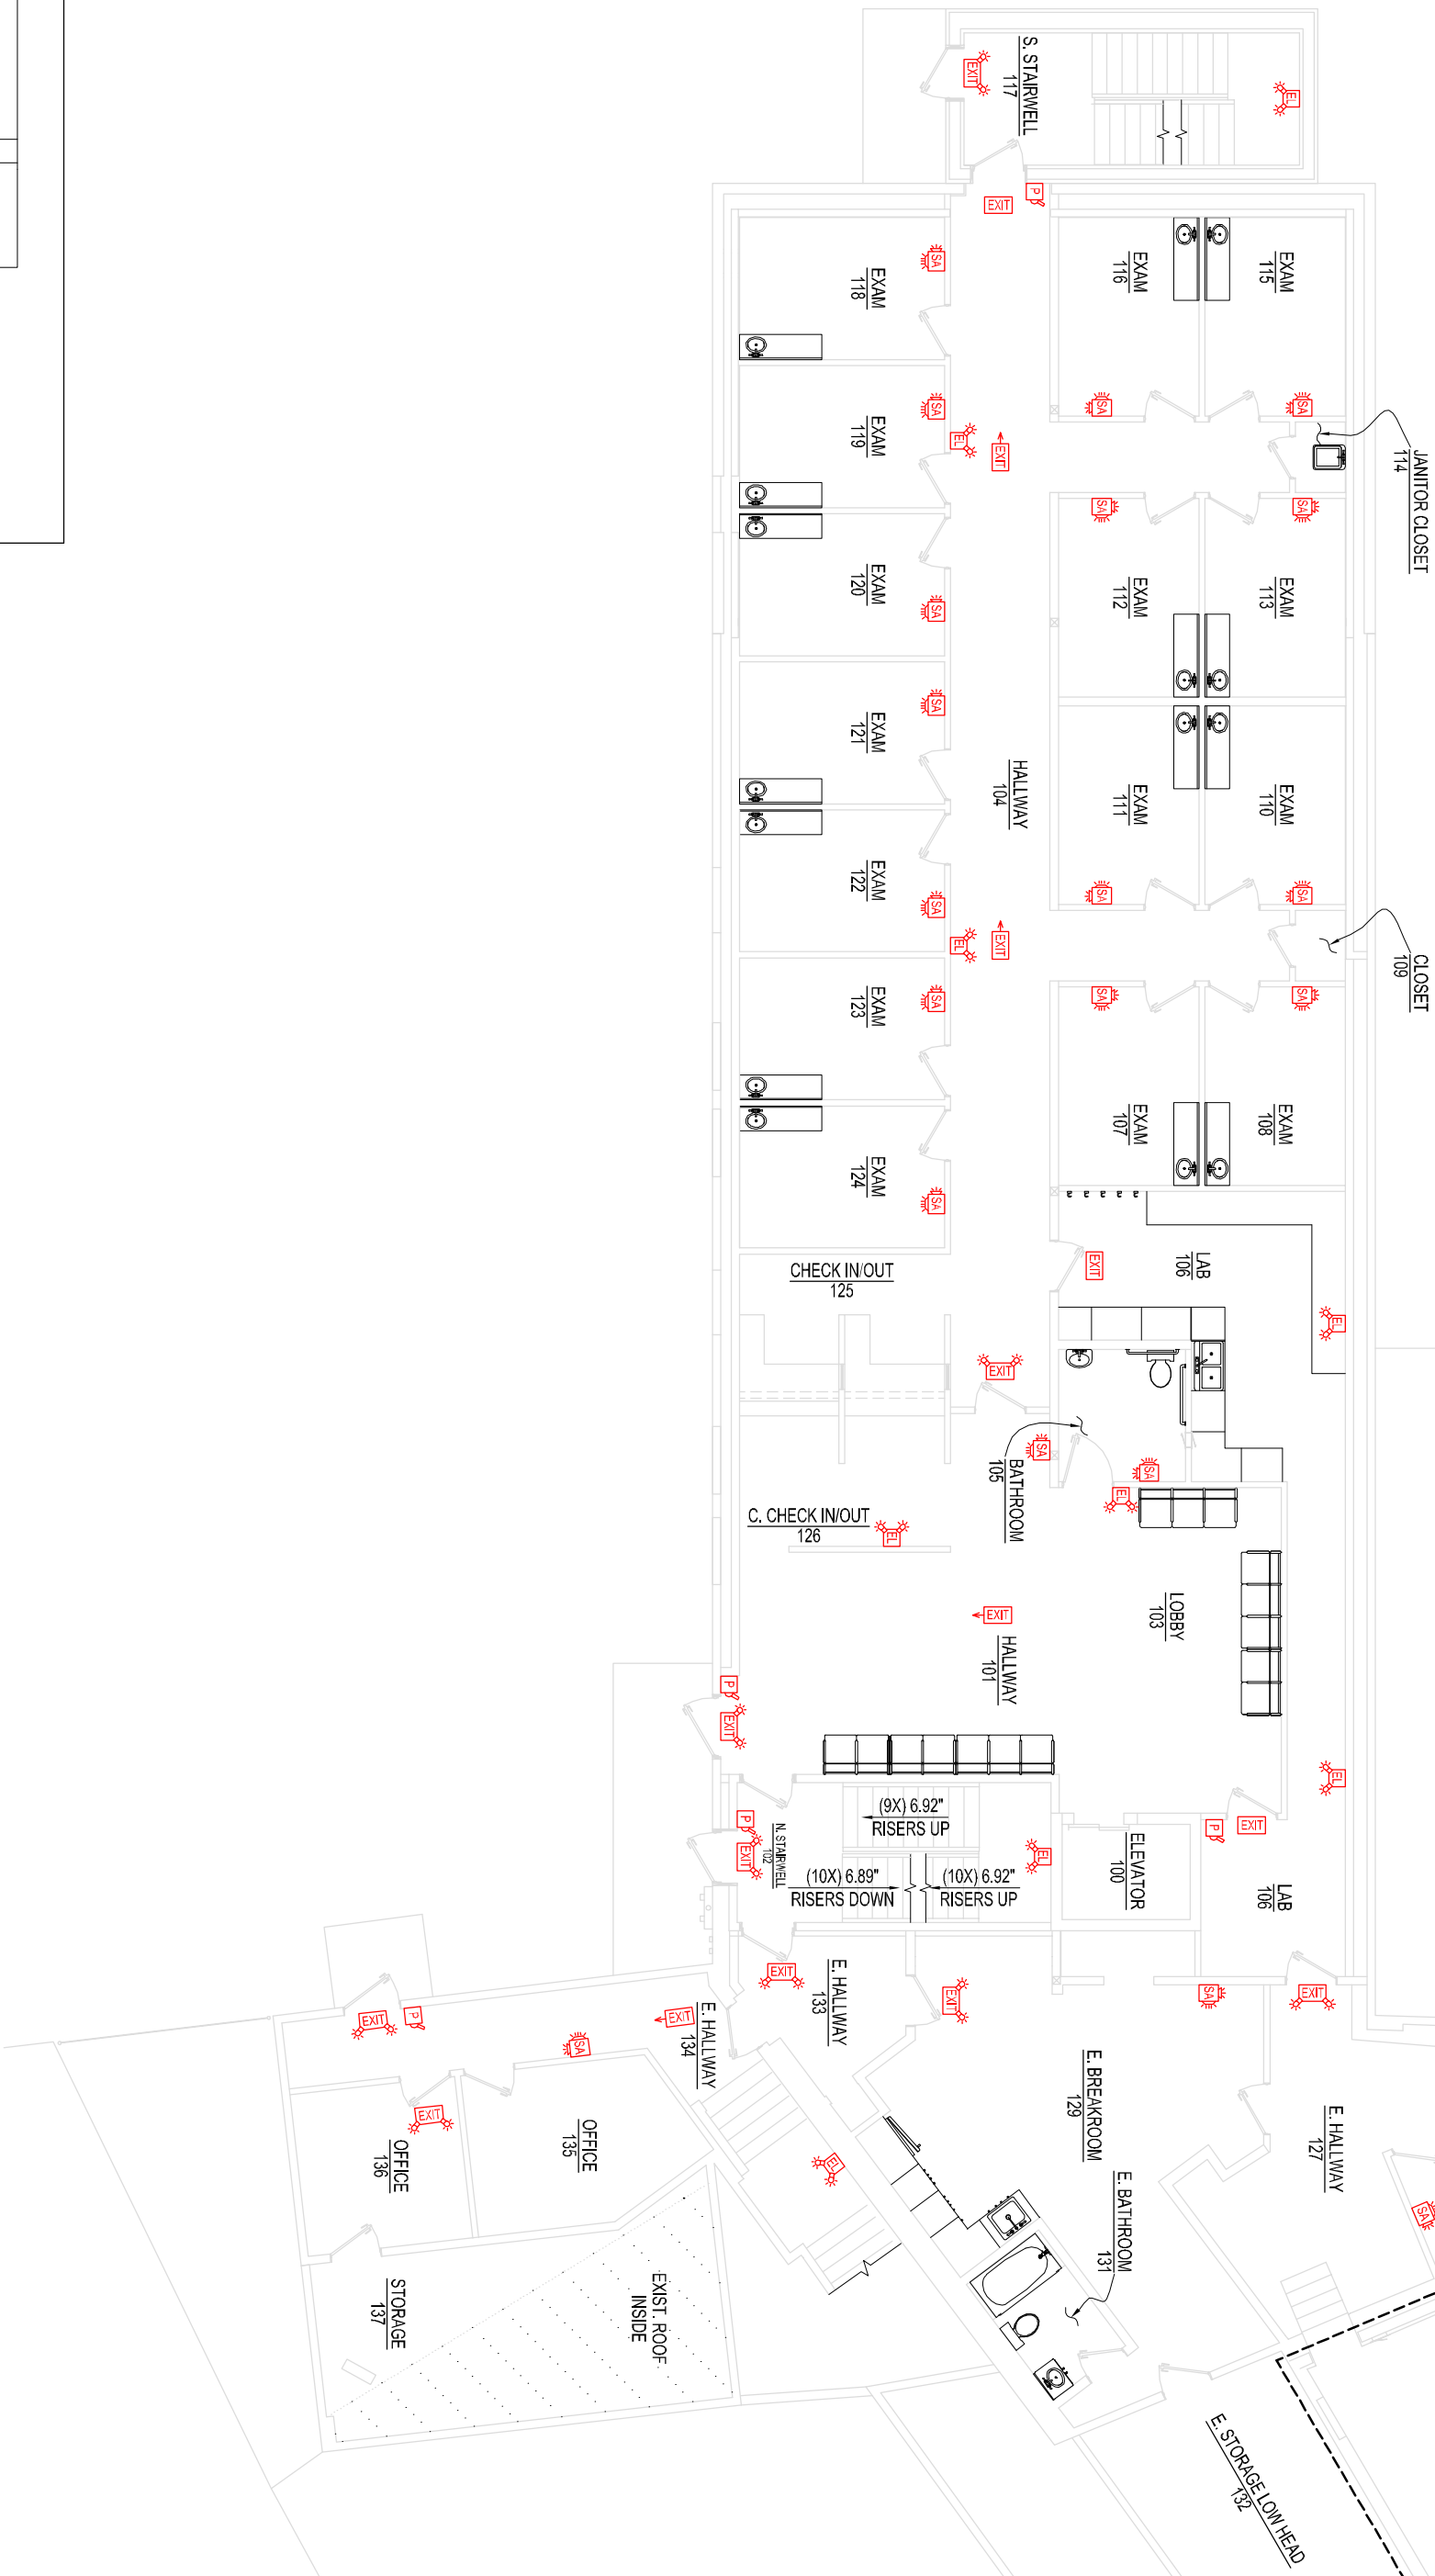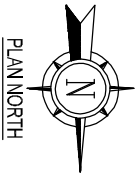

PLAN CONT.
SHEET E5

E. RESTROOM
128

E. HALLWAY
127

E. STORAGE LOW HEAD
132

E. BATHROOM
131

E. BREAKROOM
129

HALLWAY
101

BATHROOM
105

LAB
106

EXAM
108

EXAM
111

EXAM
112

EXAM
113

EXAM
115

S. STAIRWELL
117

CHECK IN/OUT
125

C. CHECK IN/OUT
126

(9X) 6.92"
RISERS UP

(10X) 6.89"
RISERS DOWN

(10X) 6.92"
RISERS UP

E. HALLWAY
133

E. HALLWAY
134

OFFICE
133


OFFICE
136

STORAGE
137

EXIST. ROOF
INSIDE

JANITOR CLOSET
114

CLOSET
109

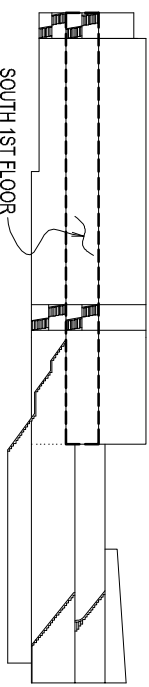

ELEVATION KEY

NOTES:
1.) ROOM LABEL #130 NOT USED.

HEALTH CENTER 1ST FLOOR LIFE SAFETY ELEC. FLOOR PLAN

SCALE: 3/32 IN. = 1 FT.

NOT FOR CONSTRUCTION
FOR REVIEW ONLY
REV 06

 
HEALTH CENTER 1ST FLOOR LIFE SAFETY ELEC. FLOOR PLAN

ST. CROIX HEALTH CENTER
MAIN STREET
CALAIS, MAINE



THIS DRAWING IS AN INSTRUMENT
DESIGNED TO FACILITATE THE WORK
UNDER THE JOB NUMBER INDICATED.
IT IS THE PROPERTY OF FORESIGHT
ENGINEERING AND IS NOT TO BE USED
FOR OTHER WORK ACCEPT BY
WRITTEN AGREEMENT WITH
FORESIGHT ENGINEERING.

FORESIGHT ENGINEERING P.C.

10 FLEMING STREET
LINCOLN, MAINE 04457
(207) 794-2775
(PHONE OR FAX)



 DATE: 9/21/26
SCALE: NOTED
DRAWN: MST
JOB NO: 26001E
E4

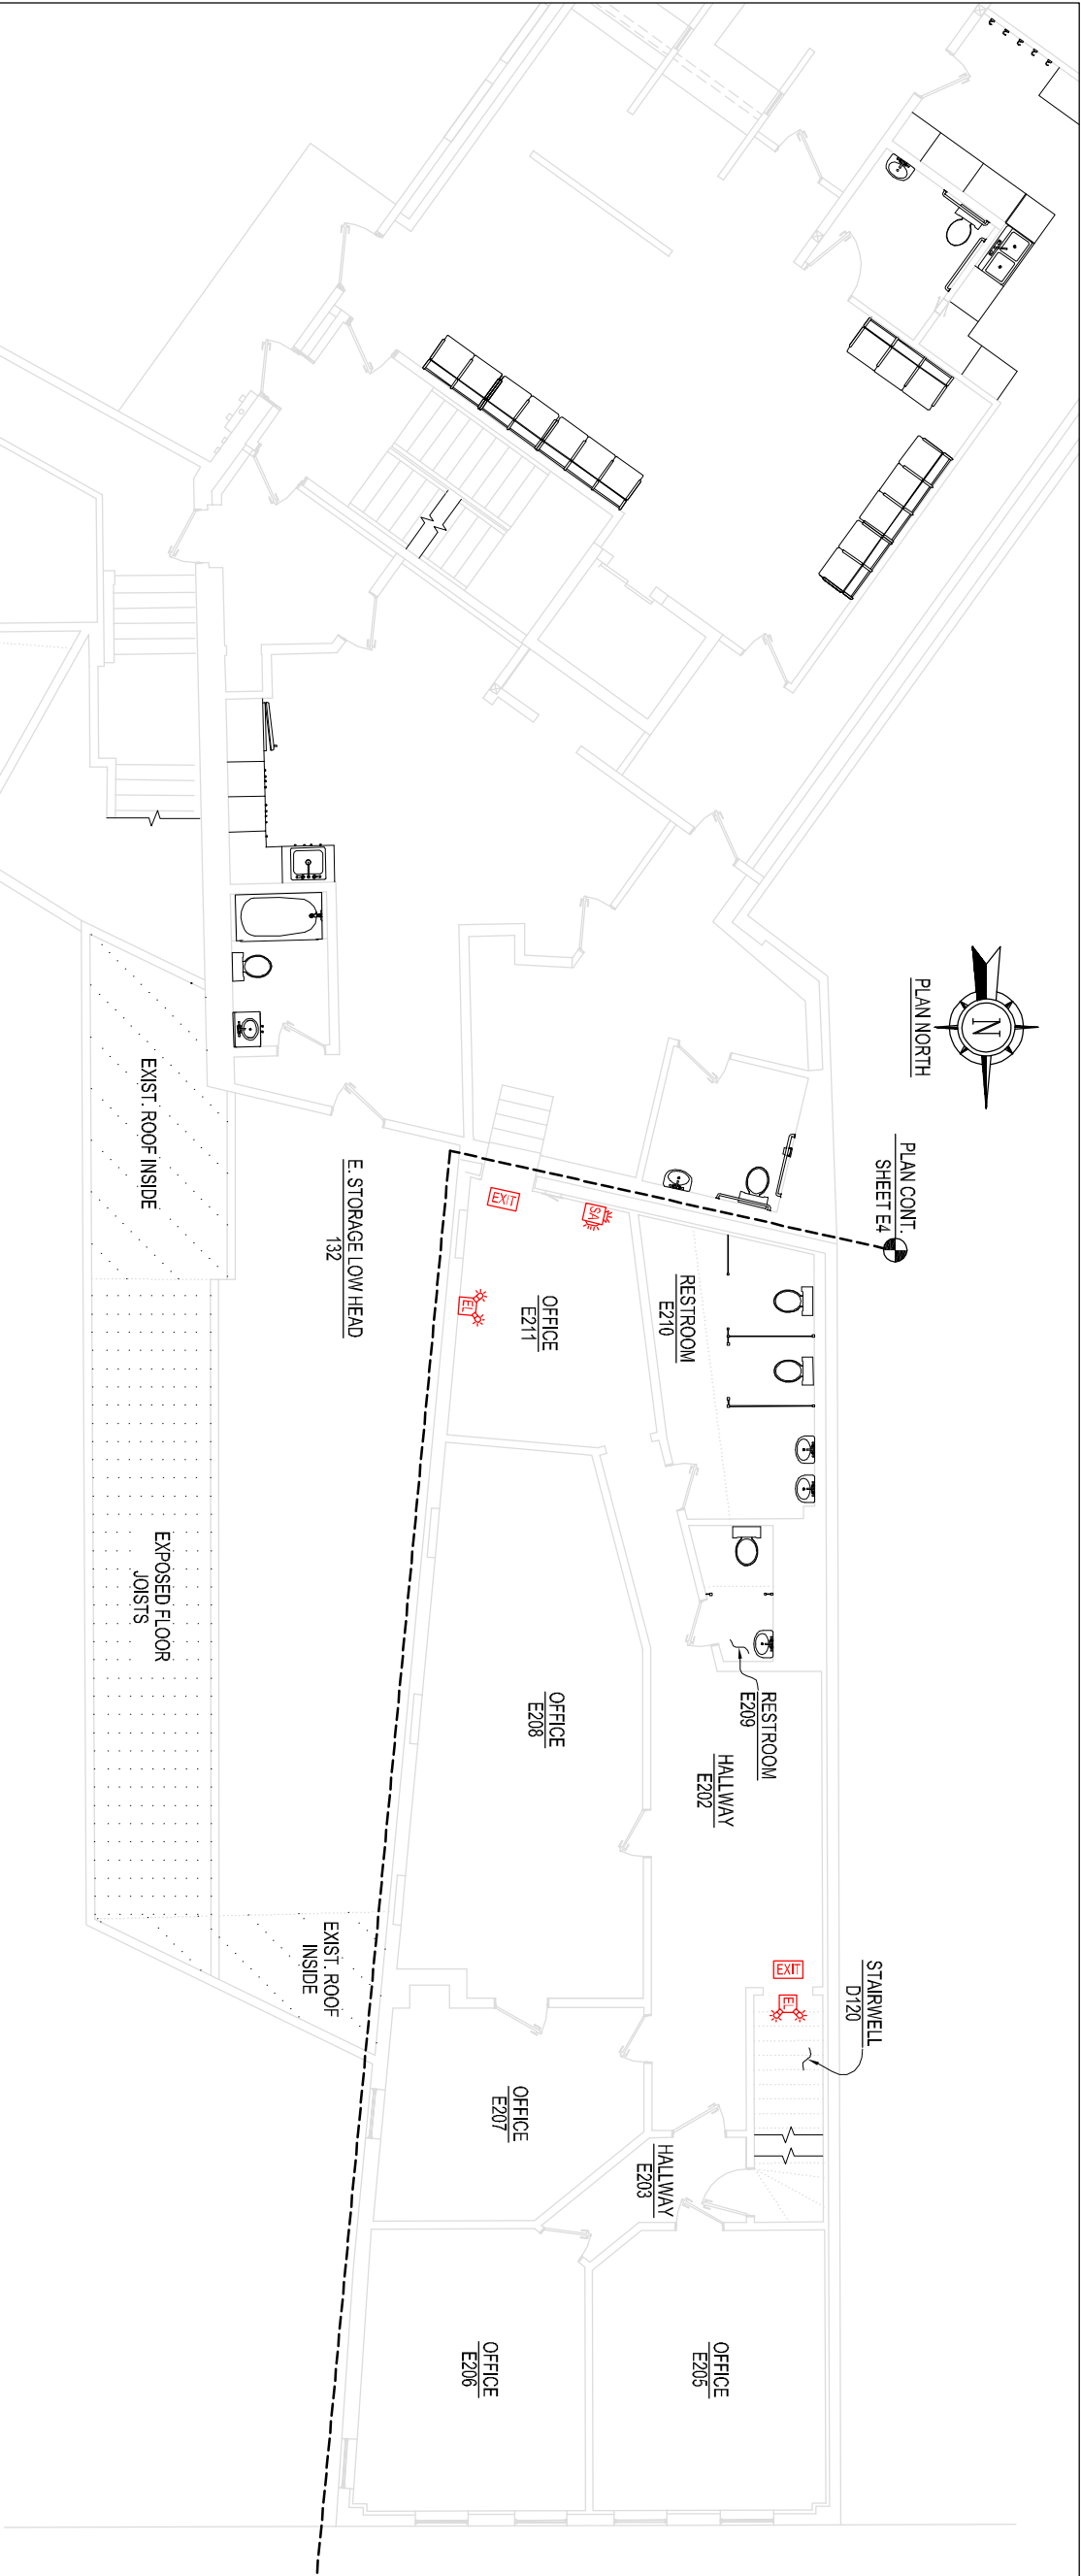

PLAN NORTH

PLAN CONT.
SHEET E4

STAIRWELL
D120

EXIT
E209

RESTROOM
E209

HALLWAY
E202

RESTROOM
E210

OFFICE
E211

EXIT
E211

OFFICE
E208

OFFICE
E207

OFFICE
E206

OFFICE
E205

 
HALLWAY
E203

E. STORAGE LOW HEAD
132

EXIST. ROOF INSIDE

EXPOSED FLOOR
JOISTS

EXIST. ROOF
INSIDE



NORTH 2ND FLOOR

ELEVATION KEY

OFFICE SPACE 2ND FLOOR LIFE SAFETY ELEC. FLOOR PLAN

SCALE: 3/32 IN. = 1 FT.

 
OFFICE SPACE 2ND FLOOR LIFE SAFETY ELEC. FLOOR PLAN

ST. CROIX HEALTH CENTER
MAIN STREET
CALAIS, MAINE

THIS DRAWING IS AN INSTRUMENT
DESIGNED TO FACILITATE THE WORK
UNDER THE JOB NUMBER INDICATED.
IT IS THE PROPERTY OF FORESIGHT
ENGINEERING AND IS NOT TO BE USED
FOR OTHER WORK ACCEPT BY
WRITTEN AGREEMENT WITH
FORESIGHT ENGINEERING.

FORESIGHT ENGINEERING P.C.

10 FLEMING STREET
LINCOLN, MAINE 04457
(207) 794-2775
(PHONE OR FAX)



DATE: 9/21/26



SCALE: NOTED

DRAWN: MST

JOB NO: 26001E

E5


NOT FOR CONSTRUCTION
FOR REVIEW ONLY
REV 06

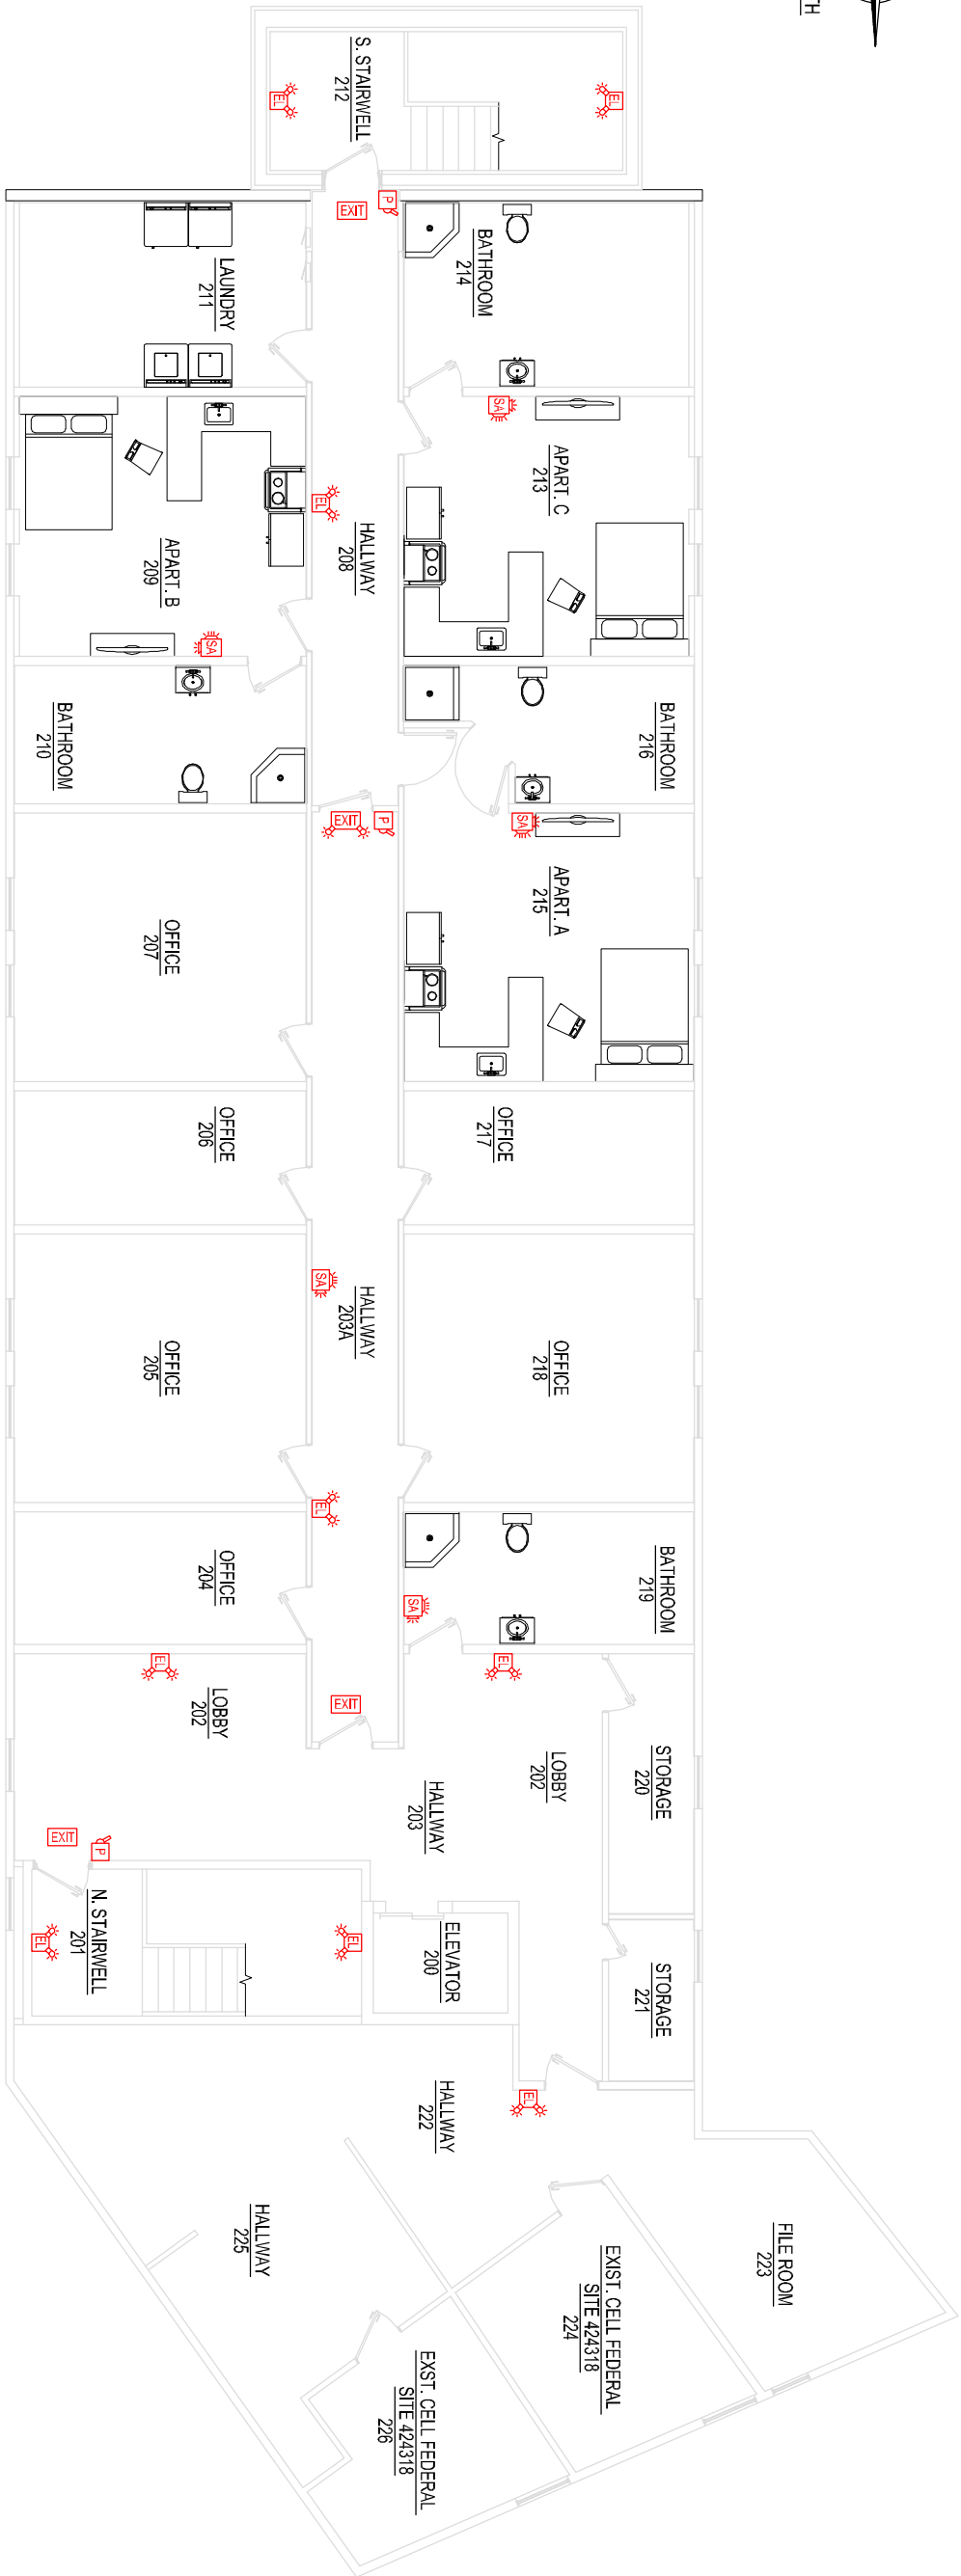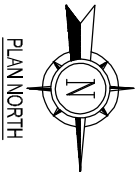


APARTMENTS 2ND FLOOR LIFE SAFETY ELEC. FLOOR PLAN

SCALE: 3/32 IN. = 1 FT.

SOUTH 2ND FLOOR

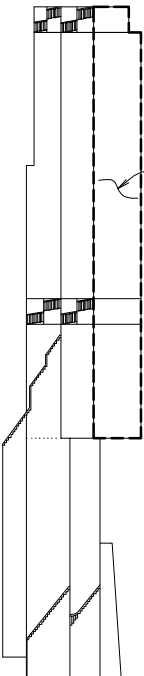

ELEVATION KEY

 




FORESIGHT ENGINEERING P.C.
10 FLEMING STREET
LINCOLN, MAINE 04457
(207) 794-2775
(PHONE OR FAX)

THIS DRAWING IS AN INSTRUMENT
DESIGNED TO FACILITATE THE WORK
UNDER THE JOB NUMBER INDICATED.
IT IS THE PROPERTY OF FORESIGHT
ENGINEERING AND IS NOT TO BE USED
FOR OTHER WORK ACCEPT BY
WRITTEN AGREEMENT WITH
FORESIGHT ENGINEERING.

APARTMENTS 2ND FLOOR LIFE SAFETY ELEC. FLOOR PLAN
ST. CROIX HEALTH CENTER
MAIN STREET
CALAIS, MAINE

DATE: 9/21/26
SCALE: NOTED
DRAWN: MST
JOB NO: 26001E
E6

NOT FOR CONSTRUCTION
FOR REVIEW ONLY
REV OF

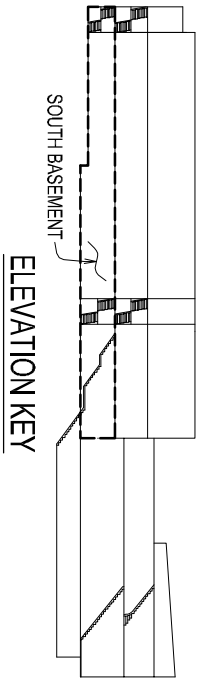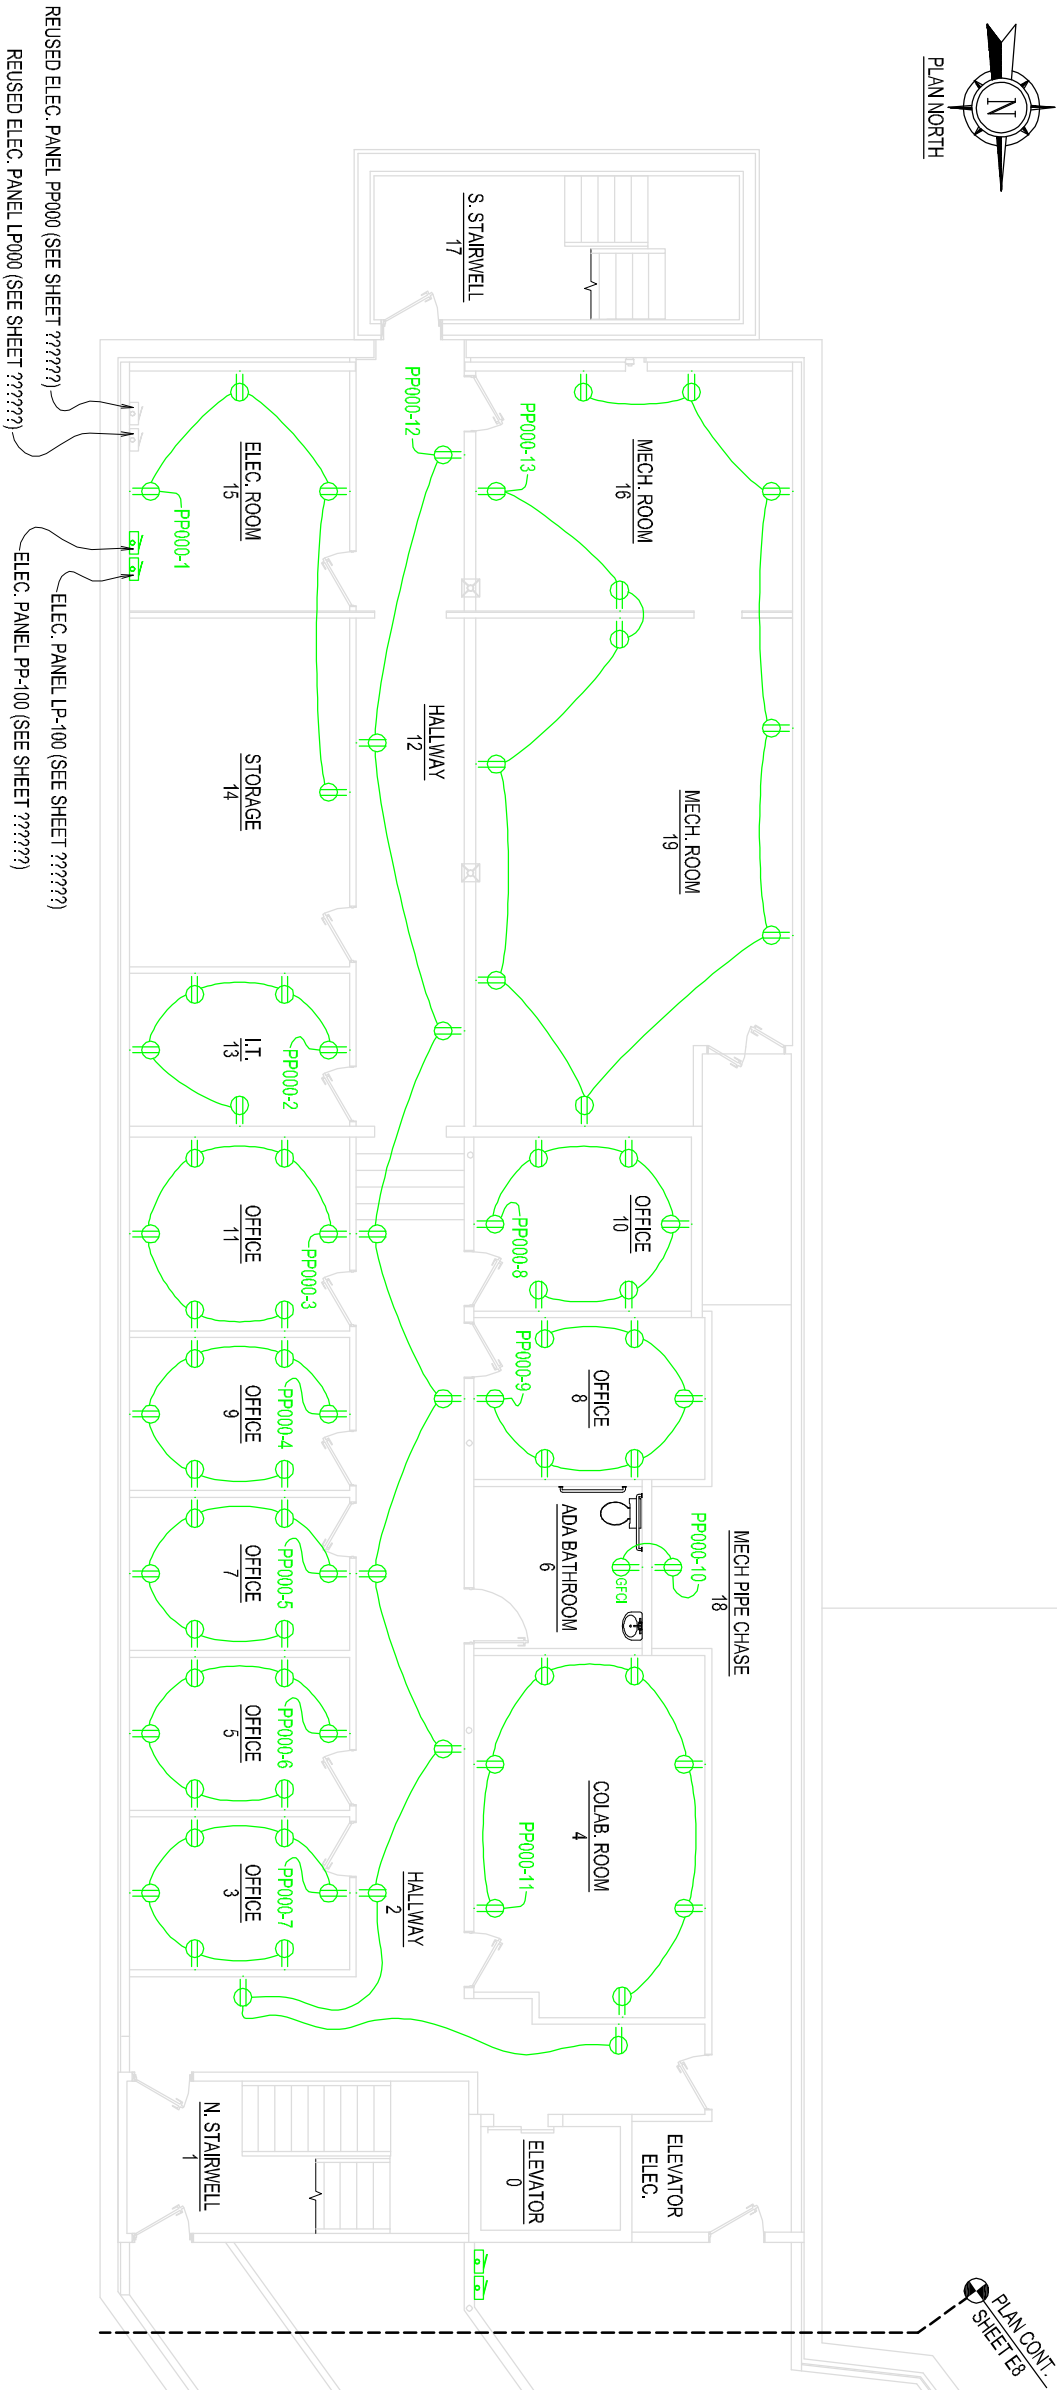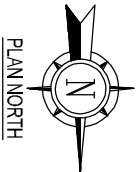

HEALTH CENTER BASEMENT RECEPTICAL FLOOR PLAN

SCALE: 3/32 IN. = 1 FT.

NOT FOR CONSTRUCTION
FOR REVIEW ONLY

 
HEALTH CENTER BASEMENT RECEPTICAL FLOOR PLAN

ST. CROIX HEALTH CENTER
MAIN STREET
CALAIS, MAINE


THIS DRAWING IS AN INSTRUMENT
DESIGNED TO FACILITATE THE WORK
UNDER THE JOB NUMBER INDICATED.
IT IS THE PROPERTY OF FORESIGHT
ENGINEERING AND IS NOT TO BE USED
FOR OTHER WORK ACCEPT BY
WRITTEN AGREEMENT WITH
FORESIGHT ENGINEERING.

FORESIGHT ENGINEERING P.C.

10 FLEMING STREET
LINCOLN, MAINE 04457
(207) 794-2775
(PHONE OR FAX)



DATE: 9/21/26
SCALE: NOTED
DRAWN: MST
JOB NO: 26001E
REV 06
E7

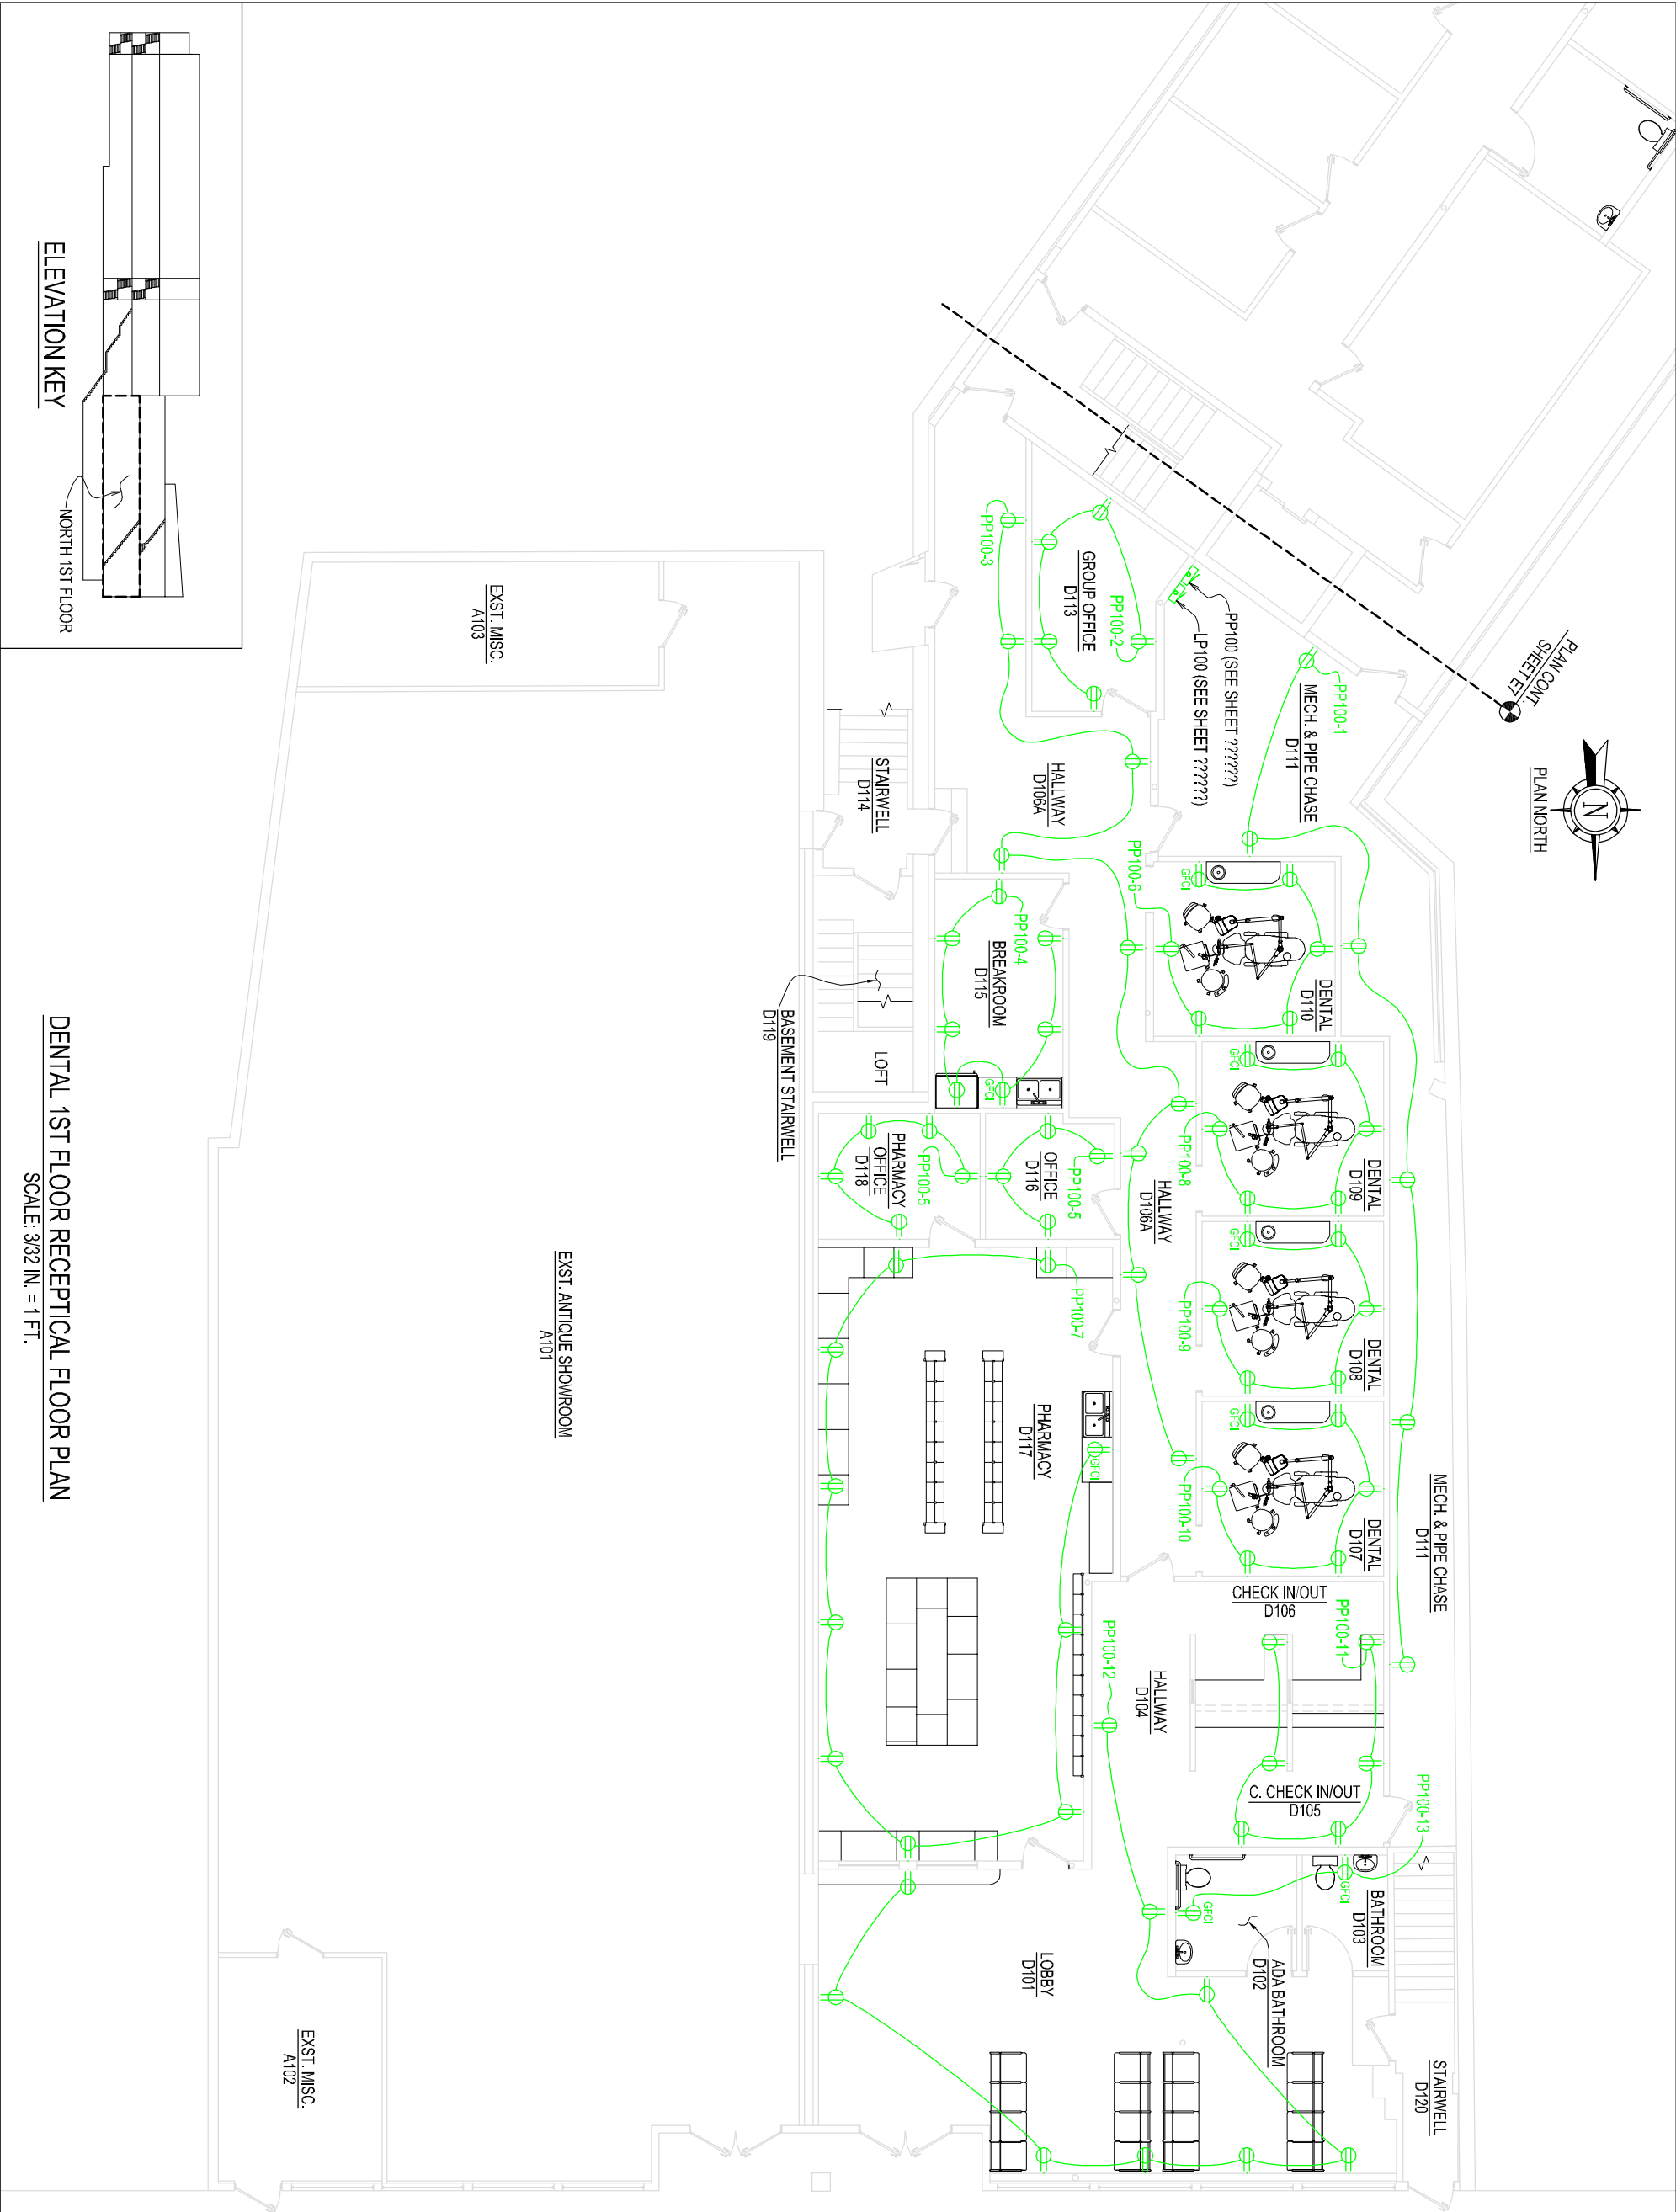

ELEVATION KEY

NORTH 1ST FLOOR

DENTAL 1ST FLOOR RECEPTICAL FLOOR PLAN

SCALE: 3/32 IN. = 1 FT.

NOT FOR CONSTRUCTION
FOR REVIEW ONLY
REV 06

 
DENTAL 1ST FLOOR RECEPTICAL FLOOR PLAN

ST. CROIX HEALTH CENTER
MAIN STREET
CALAIS, MAINE



THIS DRAWING IS AN INSTRUMENT
DESIGNED TO FACILITATE THE WORK
UNDER THE JOB NUMBER INDICATED.
IT IS THE PROPERTY OF FORESIGHT
ENGINEERING AND IS NOT TO BE USED
FOR OTHER WORK ACCEPT BY
WRITTEN AGREEMENT WITH
FORESIGHT ENGINEERING.

FORESIGHT ENGINEERING P.C.

10 FLEMING STREET
LINCOLN, MAINE 04457
(207) 794-2775
(PHONE OR FAX)



DATE: 9/21/26
SCALE: NOTED
DRAWN: MST
JOB NO: 26001E
E8

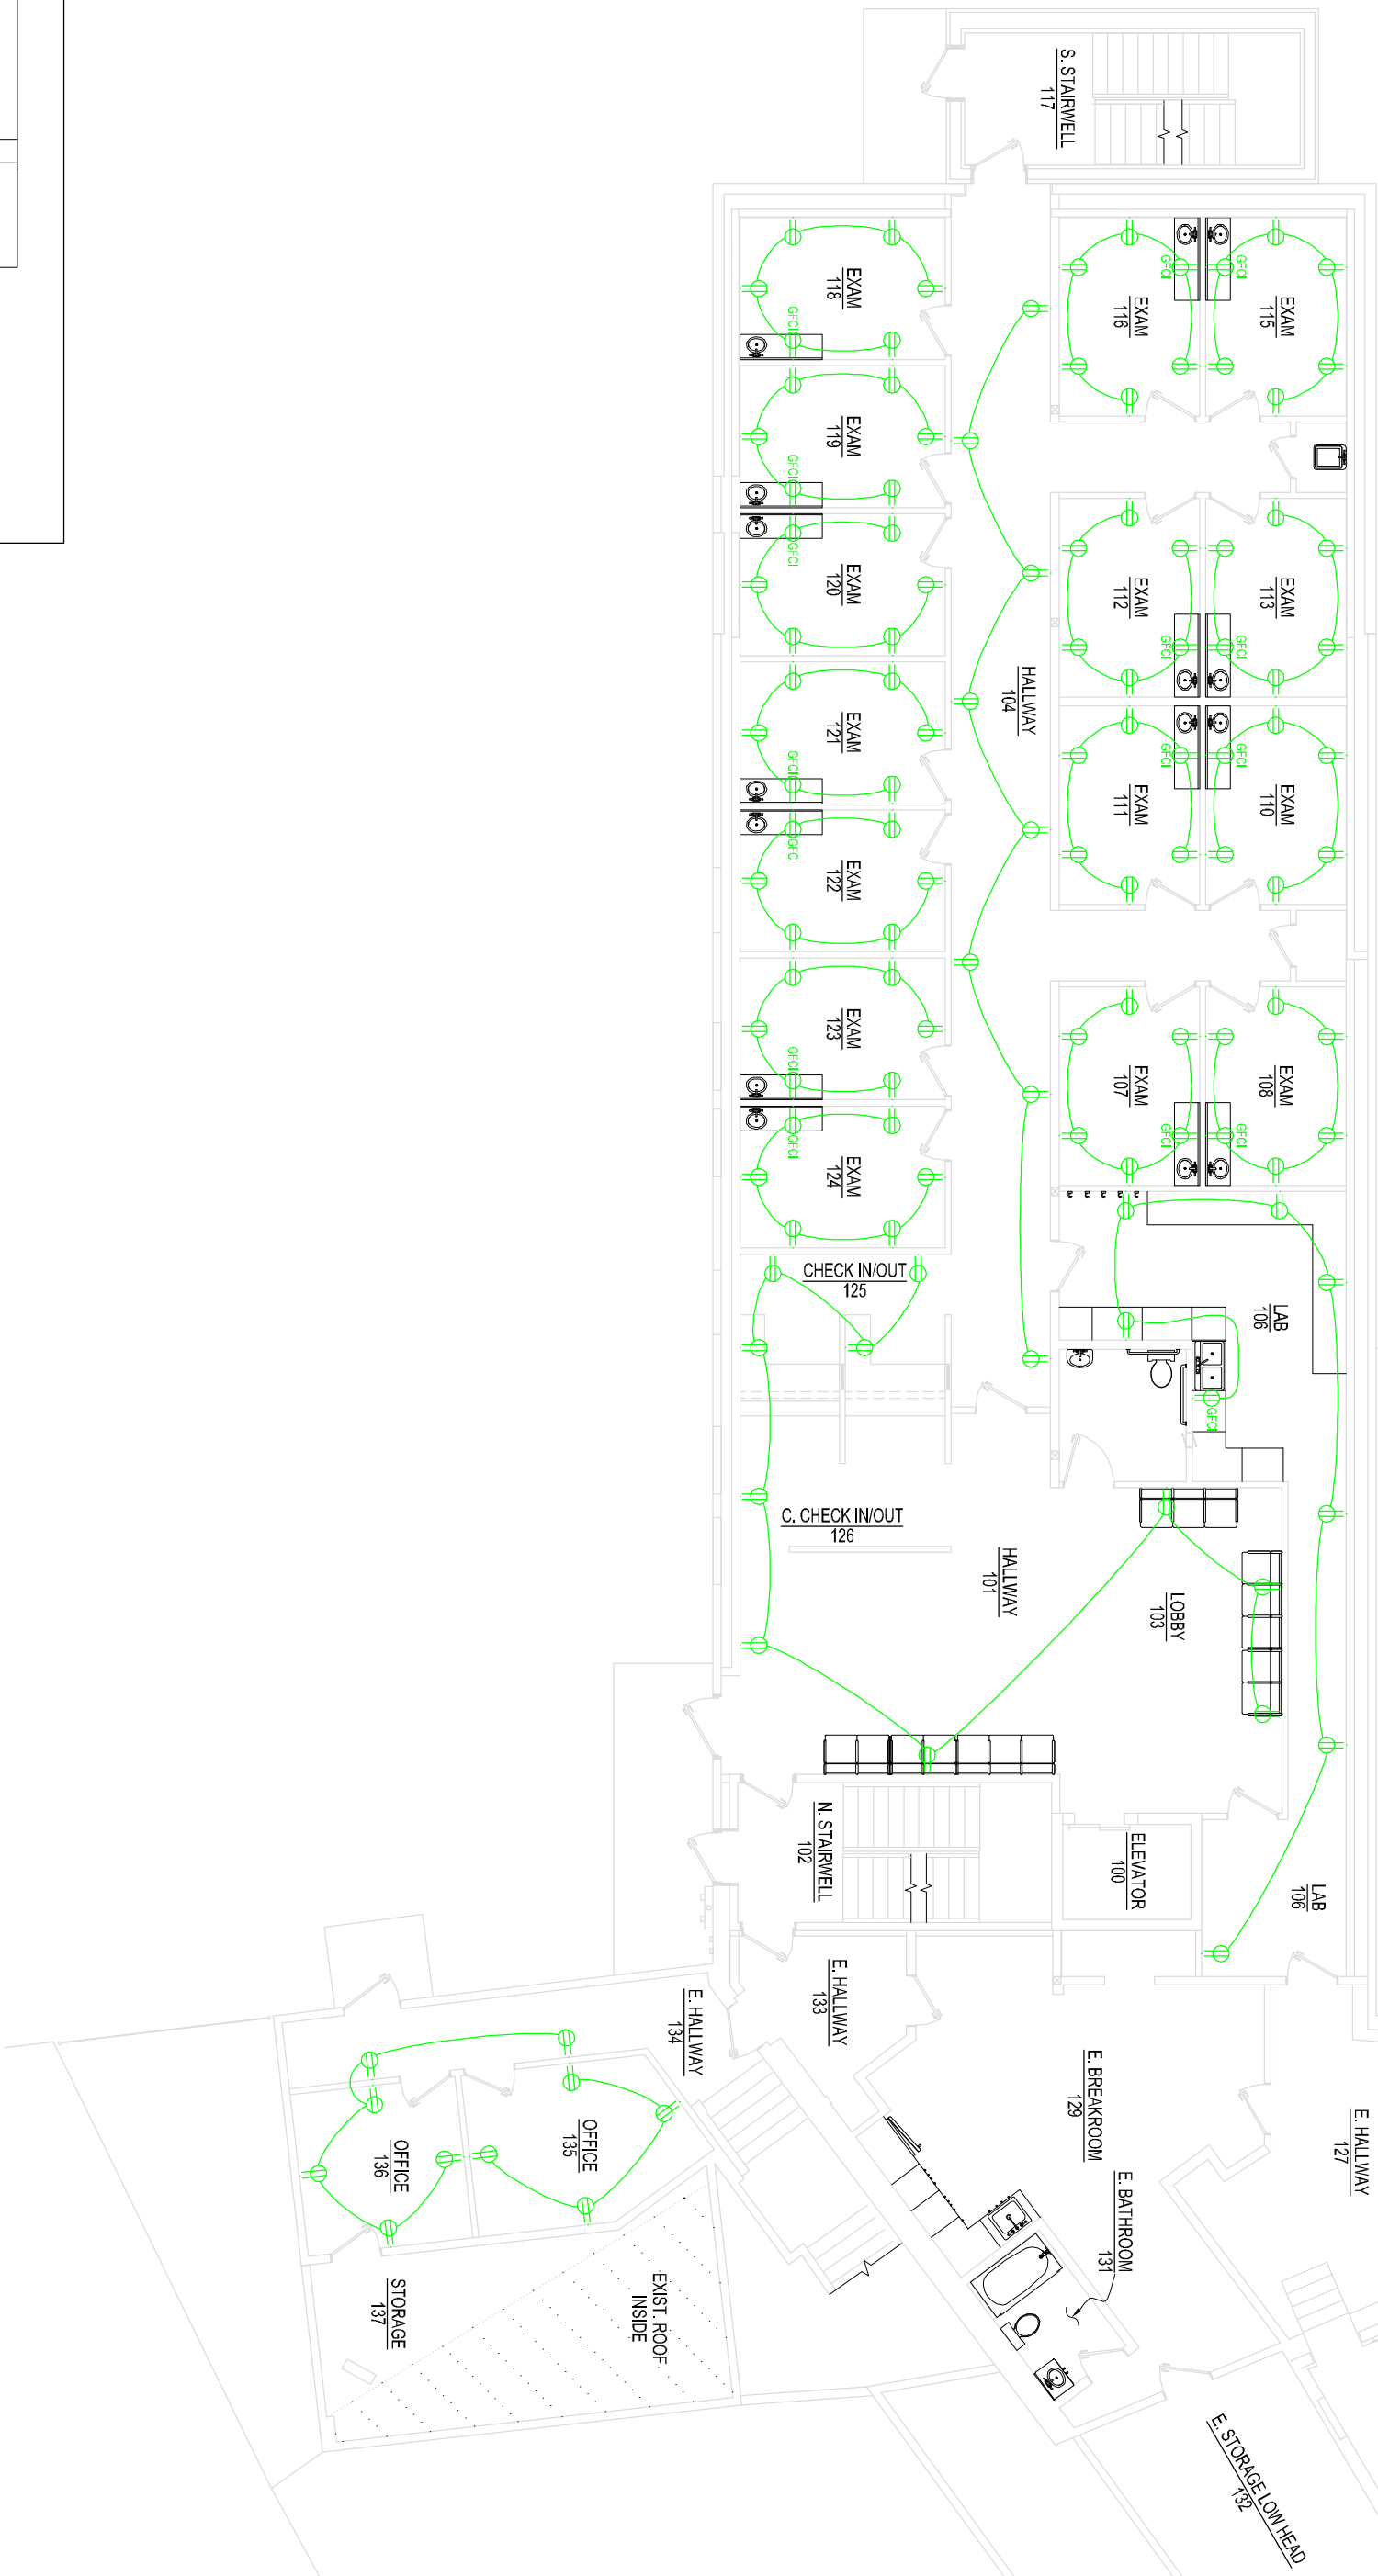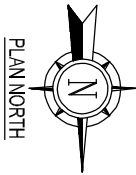


NOTES:
1.) ROOM LABEL #130 NOT USED.

HEALTH CENTER 1ST FLOOR RECEPTICAL FLOOR PLAN

SCALE: 3/32 IN. = 1 FT.

ELEVATION KEY

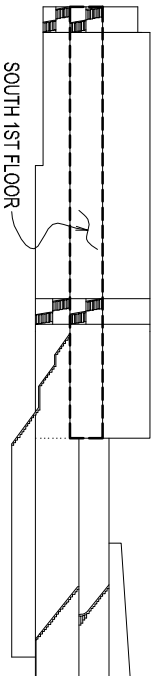

FOR REVIEW ONLY
REV 06

 
HEALTH CENTER 1ST FLOOR RECEPTICAL FLOOR PLAN

ST. CROIX HEALTH CENTER
MAIN STREET
CALAIS, MAINE



THIS DRAWING IS AN INSTRUMENT
DESIGNED TO FACILITATE THE WORK
UNDER THE JOB NUMBER INDICATED.
IT IS THE PROPERTY OF FORESIGHT
ENGINEERING AND IS NOT TO BE USED
FOR OTHER WORK ACCEPT BY
WRITTEN AGREEMENT WITH
FORESIGHT ENGINEERING.

FORESIGHT ENGINEERING P.C.

10 FLEMING STREET
LINCOLN, MAINE 04457
(207) 794-2775
(PHONE OR FAX)



DATE: 9/21/26
SCALE: NOTED
DRAWN: MST
JOB NO: 26001E
E9

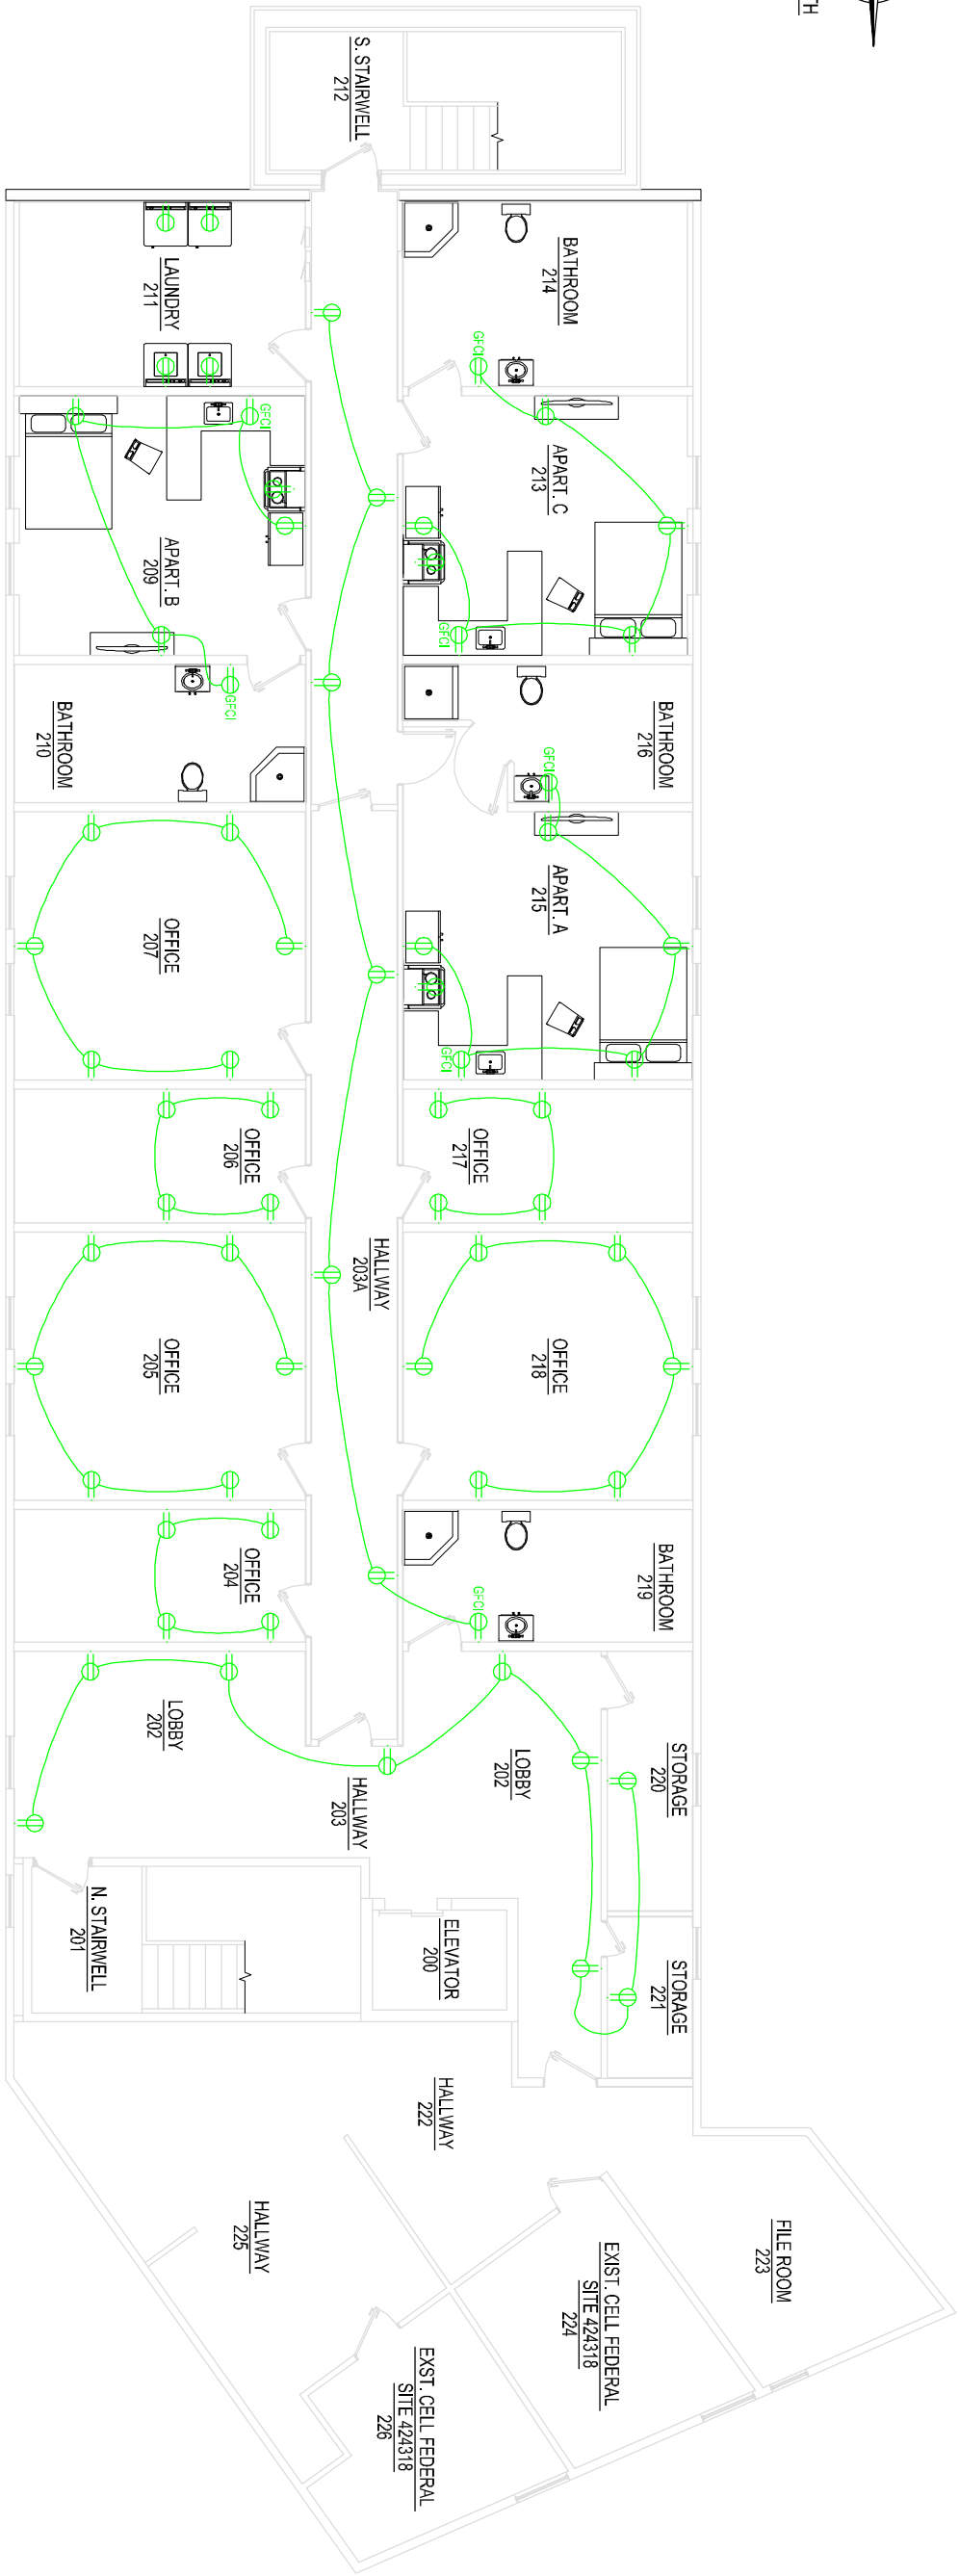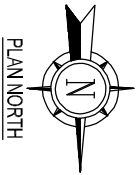

PLAN NORTH

SOUTH 2ND FLOOR

ELEVATION KEY

APARTMENTS 2ND FLOOR RECEPTICAL FLOOR PLAN

SCALE: 3/32 IN. = 1 FT.

 
APARTMENTS 2ND FLOOR RECEPTICAL FLOOR PLAN

ST. CROIX HEALTH CENTER
MAIN STREET
CALAIS, MAINE

THIS DRAWING IS AN INSTRUMENT
DESIGNED TO FACILITATE THE WORK
UNDER THE JOB NUMBER INDICATED.
IT IS THE PROPERTY OF FORESIGHT
ENGINEERING AND IS NOT TO BE USED
FOR OTHER WORK ACCEPT BY
WRITTEN AGREEMENT WITH
FORESIGHT ENGINEERING.

FORESIGHT ENGINEERING P.C.

10 FLEMING STREET
LINCOLN, MAINE 04457
(207) 794-2775
(PHONE OR FAX)



DATE: 9/21/26


SCALE: NOTED

DRAWN: MST

JOB NO: 26001E

E10

NOT FOR CONSTRUCTION
FOR REVIEW ONLY
REV 06

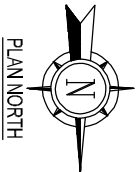


REUSED ELEC. PANEL PP000 SERVING HEALTH CENTER BASEMENT FLOOR (SEE SHEET ??????)


REUSED ELEC. PANEL LP000 SERVING HEALTH CENTER BASEMENT FLOOR (SEE SHEET ??????)

ELEC. PANEL LP-100 SERVING HEALTH CENTER 1ST FLOOR (SEE SHEET ??????)

ELEC. PANEL PP-100 SERVING HEALTH CENTER 1ST FLOOR (SEE SHEET ??????)

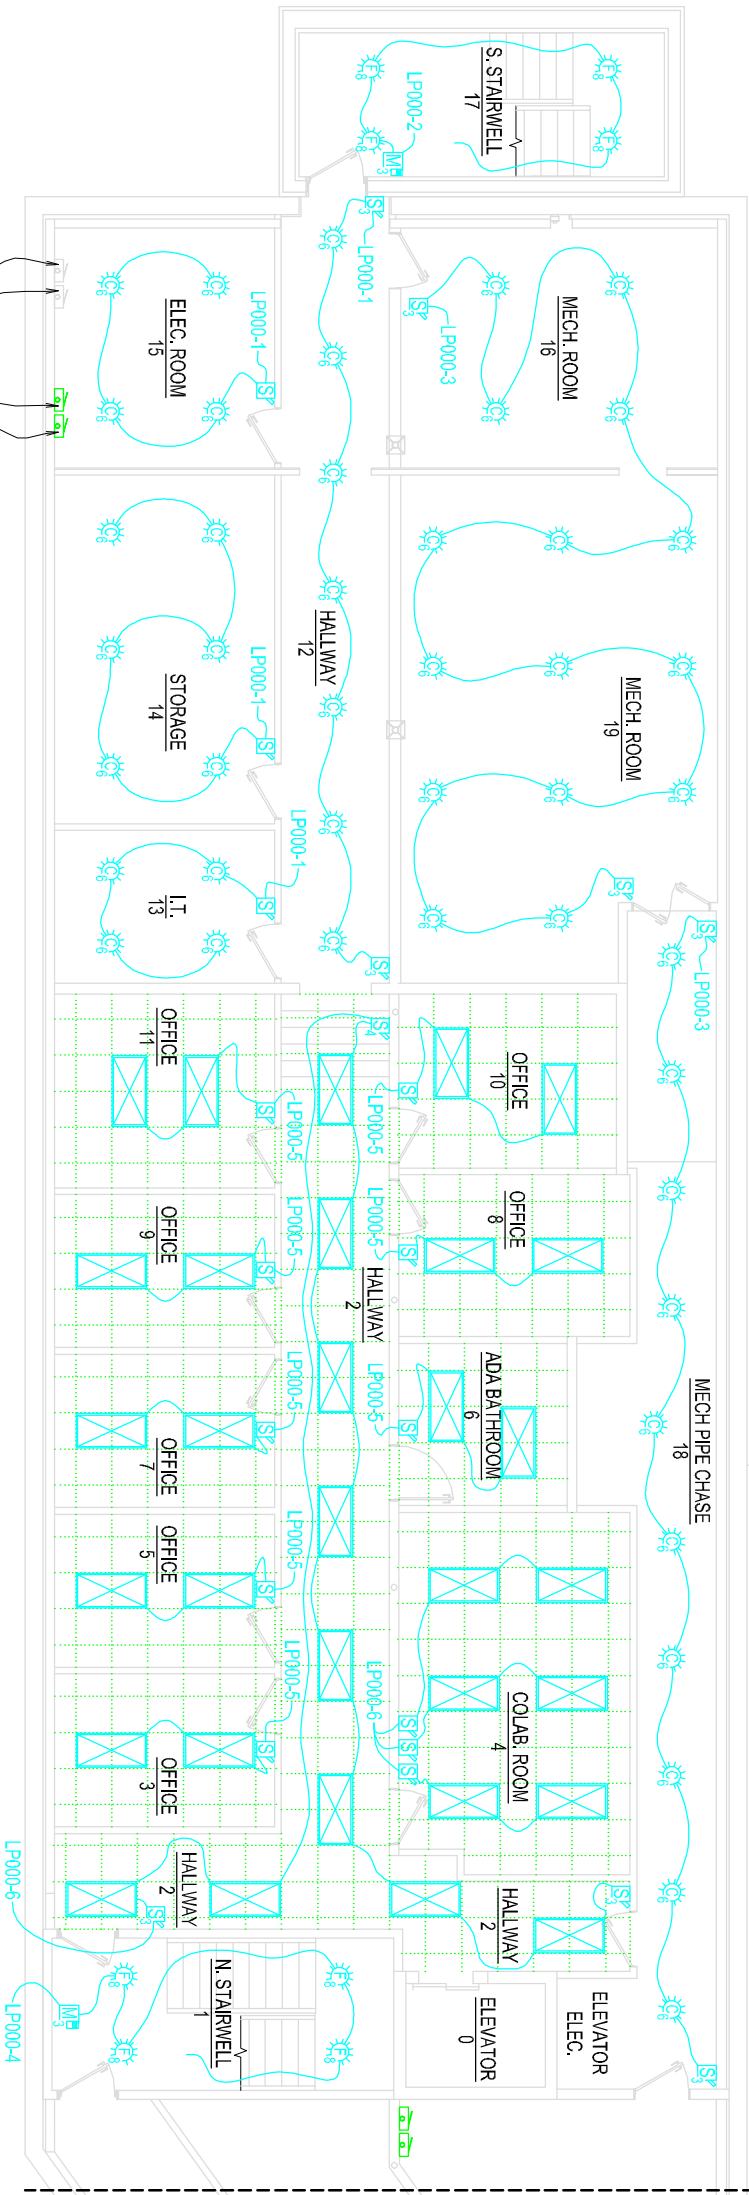

PLAN CONT.
SHEET E12

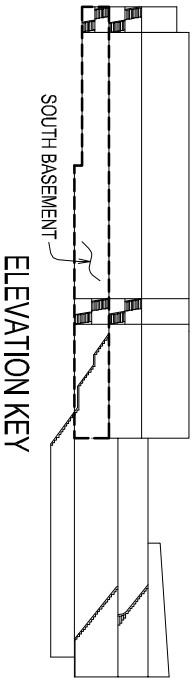

HEALTH CENTER BASEMENT LIGHTING FLOOR PLAN

SCALE: 3/32 IN. = 1 FT.

NOT FOR CONSTRUCTION
FOR REVIEW ONLY

 
HEALTH CENTER BASEMENT LIGHTING FLOOR PLAN

ST. CROIX HEALTH CENTER
MAIN STREET
CALAIS, MAINE


THIS DRAWING IS AN INSTRUMENT
DESIGNED TO FACILITATE THE WORK
UNDER THE JOB NUMBER INDICATED.
IT IS THE PROPERTY OF FORESIGHT
ENGINEERING AND IS NOT TO BE USED
FOR OTHER WORK ACCEPT BY
WRITTEN AGREEMENT WITH
FORESIGHT ENGINEERING.

FORESIGHT ENGINEERING P.C.

10 FLEMING STREET
LINCOLN, MAINE 04457
(207) 794-2775
(PHONE OR FAX)



DATE: 9/21/26
SCALE: NOTED
DRAWN: MST
JOB NO: 26001E
E11

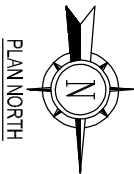

PLAN CONT.
SHEET E11

ELEVATION KEY

NORTH 1ST FLOOR

DENTAL 1ST FLOOR LIGHTING FLOOR PLAN VIEW

SCALE: 3/32 IN. = 1 FT.

NOT FOR CONSTRUCTION
FOR REVIEW ONLY
REV 06

 
DENTAL 1ST FLOOR LIGHTING FLOOR PLAN

ST. CROIX HEALTH CENTER
MAIN STREET
CALAIS, MAINE



THIS DRAWING IS AN INSTRUMENT
DESIGNED TO FACILITATE THE WORK
UNDER THE JOB NUMBER INDICATED.
IT IS THE PROPERTY OF FORESIGHT
ENGINEERING AND IS NOT TO BE USED
FOR OTHER WORK ACCEPT BY
WRITTEN AGREEMENT WITH
FORESIGHT ENGINEERING.

FORESIGHT ENGINEERING P.C.

10 FLEMING STREET
LINCOLN, MAINE 04457
(207) 794-2775
(PHONE OR FAX)




DATE: 9/21/26
SCALE: NOTED
DRAWN: MST
JOB NO: 26001E
E12

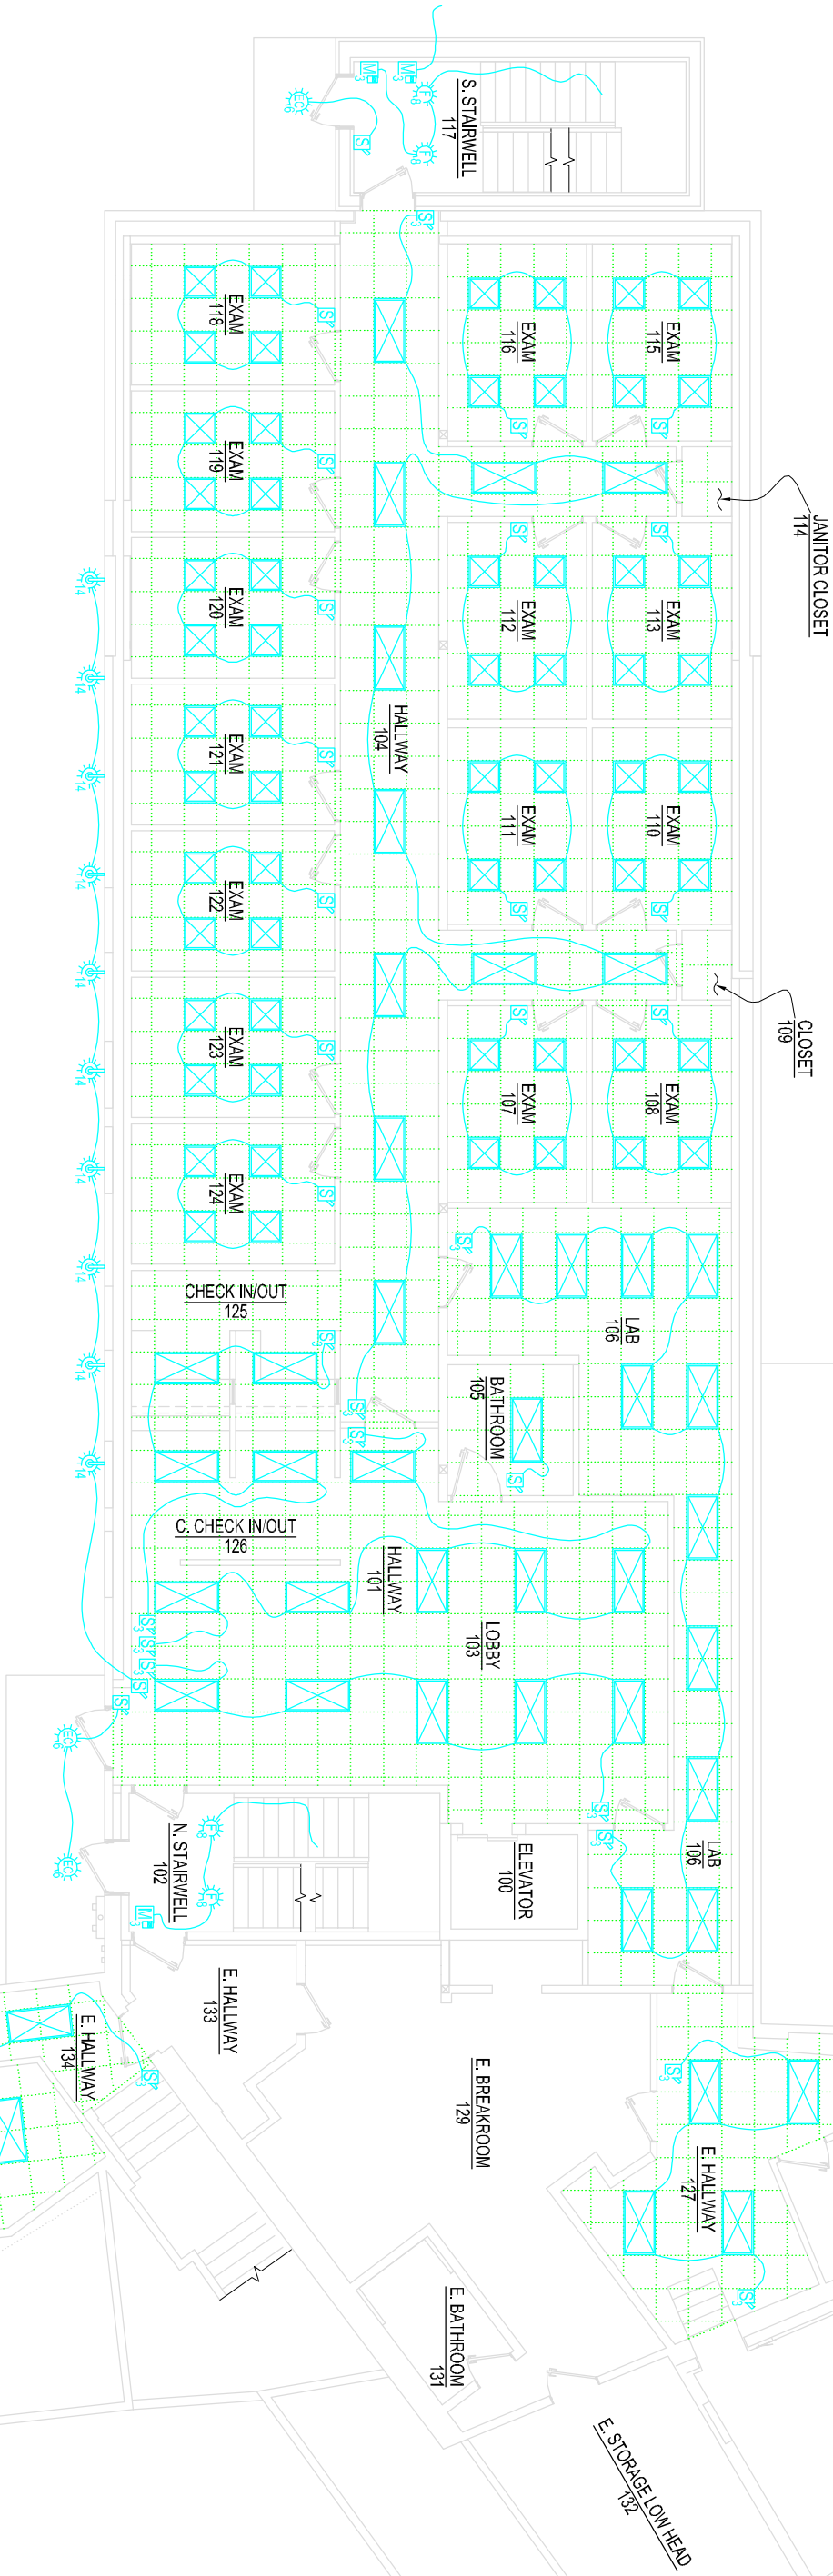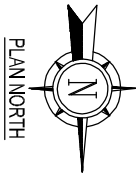


NOTES:
1.) ROOM LABEL #130 NOT USED.

HEALTH CENTER 1ST FLOOR LIGHTING FLOOR PLAN

SCALE: 3/32 IN. = 1 FT.

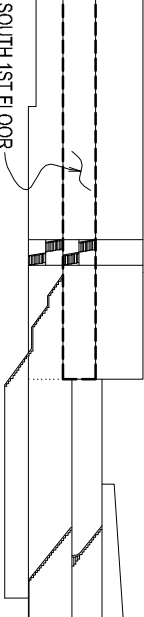

ELEVATION KEY

 



FORESIGHT ENGINEERING P.C.
10 FLEMING STREET
LINCOLN, MAINE 04457
(207) 794-2775
(PHONE OR FAX)

THIS DRAWING IS AN INSTRUMENT
DESIGNED TO FACILITATE THE WORK
UNDER THE JOB NUMBER INDICATED.
IT IS THE PROPERTY OF FORESIGHT
ENGINEERING AND IS NOT TO BE USED
FOR OTHER WORK ACCEPT BY
WRITTEN AGREEMENT WITH
FORESIGHT ENGINEERING.

HEALTH CENTER 1ST FLOOR LIGHTING FLOOR PLAN
ST. CROIX HEALTH CENTER
MAIN STREET
CALAIS, MAINE

NOT FOR CONSTRUCTION
FOR REVIEW ONLY
REV 06


DATE: 9/21/26
SCALE: NOTED
DRAWN: MST
JOB NO: 26001E
E13

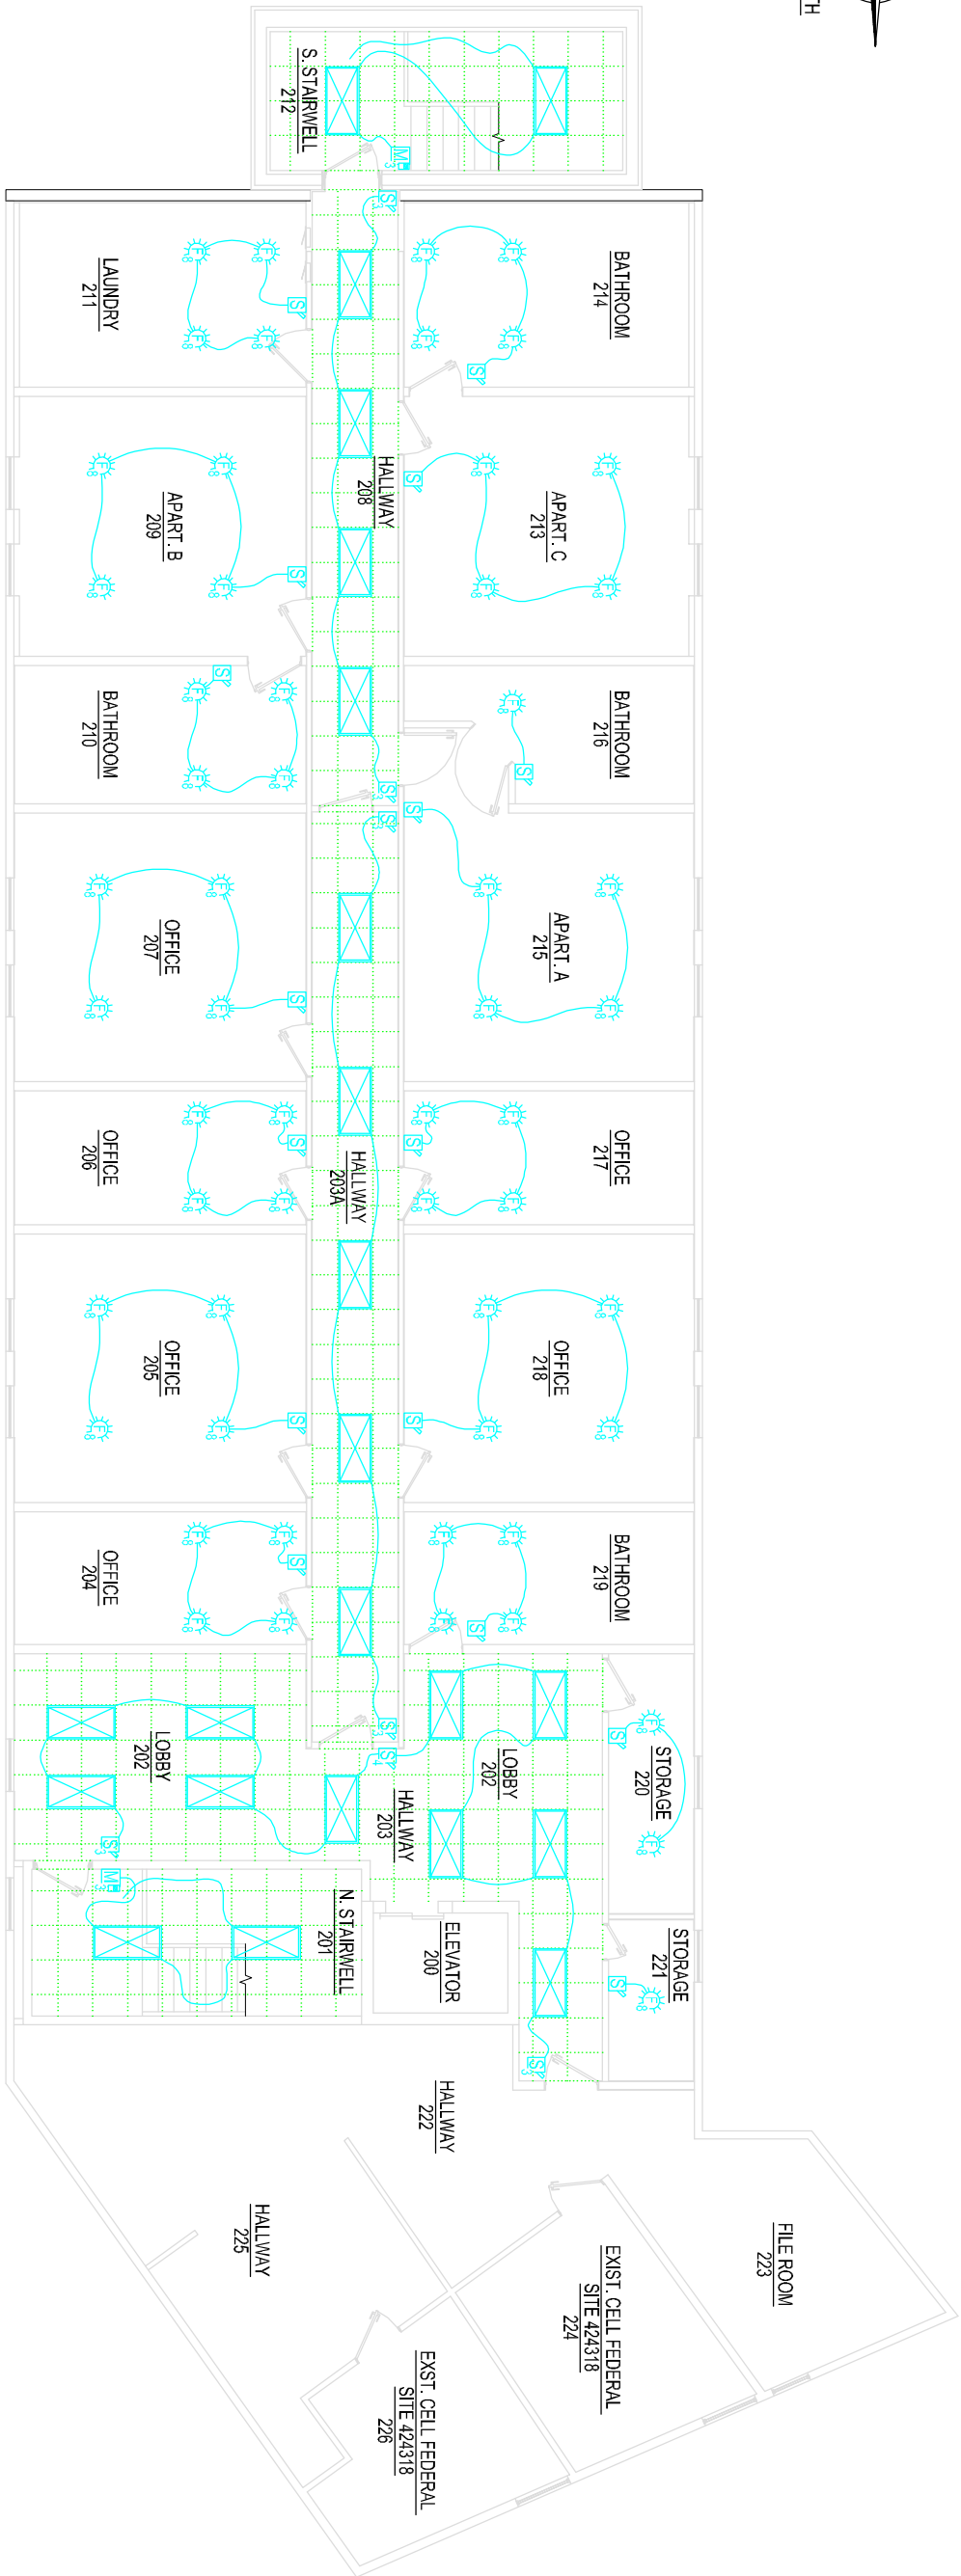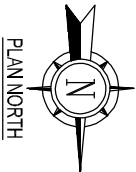

APARTMENTS 2ND FLOOR LIGHTING FLOOR PLAN

SCALE: 3/32 IN. = 1 FT.

SOUTH 2ND FLOOR

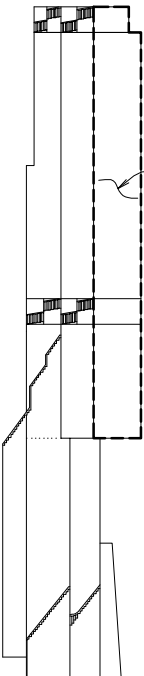

ELEVATION KEY

NOT FOR CONSTRUCTION
FOR REVIEW ONLY
REV 06

 
APARTMENTS 2ND FLOOR LIGHTING FLOOR PLAN

ST. CROIX HEALTH CENTER
MAIN STREET
CALAIS, MAINE

THIS DRAWING IS AN INSTRUMENT
DESIGNED TO FACILITATE THE WORK
UNDER THE JOB NUMBER INDICATED.
IT IS THE PROPERTY OF FORESIGHT
ENGINEERING AND IS NOT TO BE USED
FOR OTHER WORK ACCEPT BY
WRITTEN AGREEMENT WITH
FORESIGHT ENGINEERING.

FORESIGHT ENGINEERING P.C.

10 FLEMING STREET
LINCOLN, MAINE 04457
(207) 794-2775
(PHONE OR FAX)



DATE: 9/21/26
SCALE: NOTED
DRAWN: MST
JOB NO: 26001E
E14