

CONSTRUCTION NOTES

01000 GENERAL REQUIREMENTS:

- 1) ALL WORK IS NEW UNLESS INDICATED TO BE EXISTING, REUSED, OR RELOCATED.
- 2) LOCATION OF EXISTING UTILITIES SHOWN MAY NOT BE ACCURATE NOR COMPLETE. FIELD VERIFY ALL UTILITIES PRIOR TO CONSTRUCTION.
- 3) ANY EXISTING CONSTRUCTION TO REMAIN SHALL BE REPAIRED IF DAMAGED DURING THIS PROJECT.
- 4) KEEP WORK SITE IN AN ORDERLY CONDITION. DURING CONSTRUCTION, THE SITE IS TO BE LEFT FREE DRAINING. AT THE COMPLETION OF EACH DAY, REMOVE ALL WASTE AND LEAVE THE SITE IN A CONDITION ACCEPTABLE TO THE OWNER. DISPOSE OF ALL WASTE PER FEDERAL, STATE, AND LOCAL REGULATIONS.
- 5) THE INTENT OF THESE DOCUMENTS IS TO INCLUDE ALL THINGS NECESSARY FOR THE PROPER PERFORMANCE OF THE WORK. THESE DOCUMENTS ARE COMPLEMENTARY, AND WHAT IS REQUIRED BY ONE SHALL BE AS BINDING TO ALL. WORK NOT COVERED IN THESE DOCUMENTS IS NOT REQUIRED UNLESS IT IS NECESSARY TO PRODUCE THE INTENDED RESULTS.
- 6) CUSTOMARY CARE AND REVIEW WAS USED TO PREPARE THESE DRAWINGS. ALL THE DIMENSIONS SHALL BE DOUBLED CHECKED TO INSURE THEY ARE CORRECT. IT IS THE COMPLETE RESPONSIBILITY OF THE CONTRACTOR TO CHECK ALL DIMENSIONS BEFORE ORDERING, INSTALLATION, FABRICATION, ETC OF ANY MATERIALS. THIS INCLUDES REVIEW OF ALL INSTALLATION INSTRUCTION. DO NOT SCALE DIMENSIONS OFF THE DRAWING.
- 7) INSTALL ALL PRODUCTS FOLLOWING THE MANUFACTURES RECOMMENDATIONS. IF A CONFLICT OCCURS CONTACT THE ENGINEER. SUBMIT A CATALOG CUT & INSTALLATION INSTRUCTIONS FOR ALL PRODUCTS.
- 8) ANY CHANGE TO THE DRAWING OR SPECIFICATION SHALL BE APPROVED BY THE ENGINEER PRIOR TO INSTALLATION. CHANGES WITHOUT AN APPROVED CHANGED WILL BE REMOVED AT THE CONTRACTOR'S EXPENSE.
- 9) THE INTENT OF THIS DESIGN IS TO COMPLY WITH THE FOLLOWING CODES:
2025 MUBEC (MAINE UNIFORM BUILDING & ENERGY CODE)
THE AMERICANS WITH DISABILITIES ACT ACCESS GUIDELINES
NFPA 101-2018 (LIFE SAFETY CODE)
WHEN CONFLICTS OCCUR, CONTRACT THE ENGINEER

- GENERAL PIPING NOTES:
- 1) THE PIPING SHALL COMFORM TO THE MAINE STATE PLUMBING CODE & LOCAL RULES.
- 2) RUN PIPING PARALLEL WITH OR AT RIGHT ANGLES TO WALLS, EXCEPT AS OTHERWISE INDICTED.
- 3) PIPING PLANS ARE SCHEMATIC. THEY DO NOT INDICATE FITTINGS OR CHANGE IN ELEVATION. ALL PIPING SHALL BE CONCEALED IN THE MEP PLENUM.
- 4) ALL DETAILS IN THIS SET APPLY TO PLUMBING AS NEEDED.
- 5) PROVIDE ALL PIPING TO ALLOW EXPANSION, USE SWING JOINTS, OFFSET, EXPANSION JOINTS, ETC.
- 6) ALL PLUMBING PIPING SHALL BE LEAK TESTED PER THE MAINE STATE PLUMBING CODE, IN THE PRESENCE OF THE LOCAL PLUMBING INSPECTOR. ALL LEAKS SHALL BE REPAIRED AND THE SYSTEM OR THAT PORTION OF THE SYSTEM RETESTED.
- 7) COORDINATE ALL PLUMBING INSTALLATION WITH GENERAL, STRUCTURAL, FIRE PROTECTION, MECHANICAL, AND ELECTRICAL TRADES.
- 8) ALL VISIABLE PIPING SHALL BE LABELED PER STANDARD DETAILS.

- WATER PIPING: NOTES:
- 1) ALL HOT AND COLD WATER PIPING INSIDE THE BUILDING SHALL BE TYPE "L" COPPER.
- 2) WATER PIPING SHALL BE RUN ON THE WARM SIDE OF THE BUILDING.
- 3) ALL PLUMBING FIXTURES SHALL HAVE SHUT-OFF VALVES ON HOT AND COLD WATER SUPPLIES.
- 4) THE DESIGN PRESSURE IS 55 PSI BASED ON THE PRESSURE REGULATOR VALVE.
- 5) ALL COLD AND HOT WATER SHALL BE INSULATED WITH 1/2" CLOSED CELL TYPE INSULATION. ALL JOINTS SHALL BE SEALED AIRTIGHT WITH ARMSTRONG 520 ADHESIVE.
- 6) ALL SOLDED JOINTS IN THE PLUMBING SYSTEM SHALL BE LEAD FREE SOLDER.
- 7) INSURE THE PIPING SYSTEM HAS BEEN CLEANED, INPECTED AND PRESSURE TESTED. DISINFECT IN THE PRESENCE OF THE INSPECTOR. FLUSH PIPING TO A MINIMUM OF 3 FEET/SEC. PROVIDE A CHLORINE DOSE OF 50 MG/L FOR AT LEAST 24 HOURS. TEST AT THE END OF THE TESTING PEROID FOR CHLORINE RESIDUAL OF AT LEAST 0.5 MG/L. IF RESIDUAL IS OBTAINED CONDUCT A FINAL FLUSH ON THE SYSTEM WITH CLEAN WATER. TWO WATER SAMPLES SHALL BE COLLECTED AND TESTED FOR COLIFORM BACTERIA. ONE AT 24 AND 48 HOURS AFTER START OF PROCEDURE. FAILURE OF THE COLIFORM TEST RESTARTS THE DISINFECTION PROCEDURE. THESE PROCEDURES MAYBE ADJUSTED BY THE LOCAL CODE ENFORCEMENT.

- PROPANE PIPING NOTES:
- 1) THE PIPING SYSTEM SHALL BE PROVIDED IN ACCORDANCE WITH THE LIQUIEFIED PETROLEUM GAS CODE (NFPA 58), NATIONAL GAS CODE (NFPA 54) AND GAS SUPPLIER REQUIREMENTS.
- 2) SIZE PROPANE PIPING BASED ON 11" W.G. PRESSURE.
- 3) PIPING SHALL BE SCH. 40 BLACK IRON PAINTED YELLOW AND CLEARLY MACKED EVERY 10FT.
- 4) PIPING SHALL BE SUPPORTED FROM MIFAB C RUBBER SUPPORT SERIES, A MINIMUM OF 6FT ON CENTER. IF ON ROOF, 6" MIN. ABOVE ROOF AND PITCH TOWARD SUPPLY AT 1/4" PER 15FT.

ST. CROIX HEALTH CENTER
MAIN STREET, MAINE
PLUMBING DWGS.

INDEX


THIS INDEX INDICATES ALL THE DRAWINGS IN THIS SET COVERED BY THE P.E. STAMP. DISTRIBUTE COMPLETE DRAWINGS SETS ONLY.

- PLUMBING DRAWINGS
- P1) GENERAL NOTES & INDEX
- P2) HEALTH CENTER BASEMENT SANITARY PIPING PLAN
- P3) DENTAL 1ST FLOOR SANITARY PIPING PLAN
- P4) HEALTH CENTER 1ST FLOOR SANITARY PIPING PLAN
- P5) SHEET NOT USED
- P6) APARTMENTS 2ND FLOOR SANITARY PIPING PLAN
- P7) HEALTH CENTER BASEMENT WATER SUPPLY PLAN
- P8) DENTAL 1ST FLOOR WATER SUPPLY PLAN
- P9) HEALTH CENTER 1ST FLOOR WATER SUPPLY PLAN
- P10) OFFICE SPACE 2ND FLOOR WATER SUPPLY PLAN
- P11) APARTMENTS 2ND FLOOR WATER SUPPLY PLAN
- P12) HEALTH CENTER BASEMENT VENTILATION PLAN
- P13) DENTAL 1ST FLOOR VENTILATION PLAN
- P14) HEALTH CENTER 1ST FLOOR VENTILATION PLAN
- P15) SHEET NOT USED
- P16) APARTMENTS 2ND FLOOR VENTILATION PLAN
- P17) PLUMBING SCHEDULE
- P18) PLUMBING DETAILS 1 OF 2
- P19) PLUMBING DETAILS 2 OF 2



FORESIGHT ENGINEERING P.C.
10 FLEMING STREET
LINCOLN, MAINE 04457
(207) 794-2775
(PHONE OR FAX)


THIS DRAWING IS AN INSTRUMENT
DESIGNED TO FACILITATE THE WORK
UNDER THE JOB NUMBER INDICATED.
IT IS THE PROPERTY OF FORESIGHT
ENGINEERING AND IS NOT TO BE USED
FOR OTHER WORK ACCEPT BY
WRITTEN AGREEMENT WITH
FORESIGHT ENGINEERING.

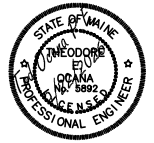

GENERAL NOTES & INDEX
ST. CROIX HEALTH CENTER
MAIN STREET
CALAIS, MAINE


DATE: 09/22/26
SCALE: NOTED
DRAWN: LW
JOB NO: 26001P
P1

FOR CONSTRUCTION
REV 0/08

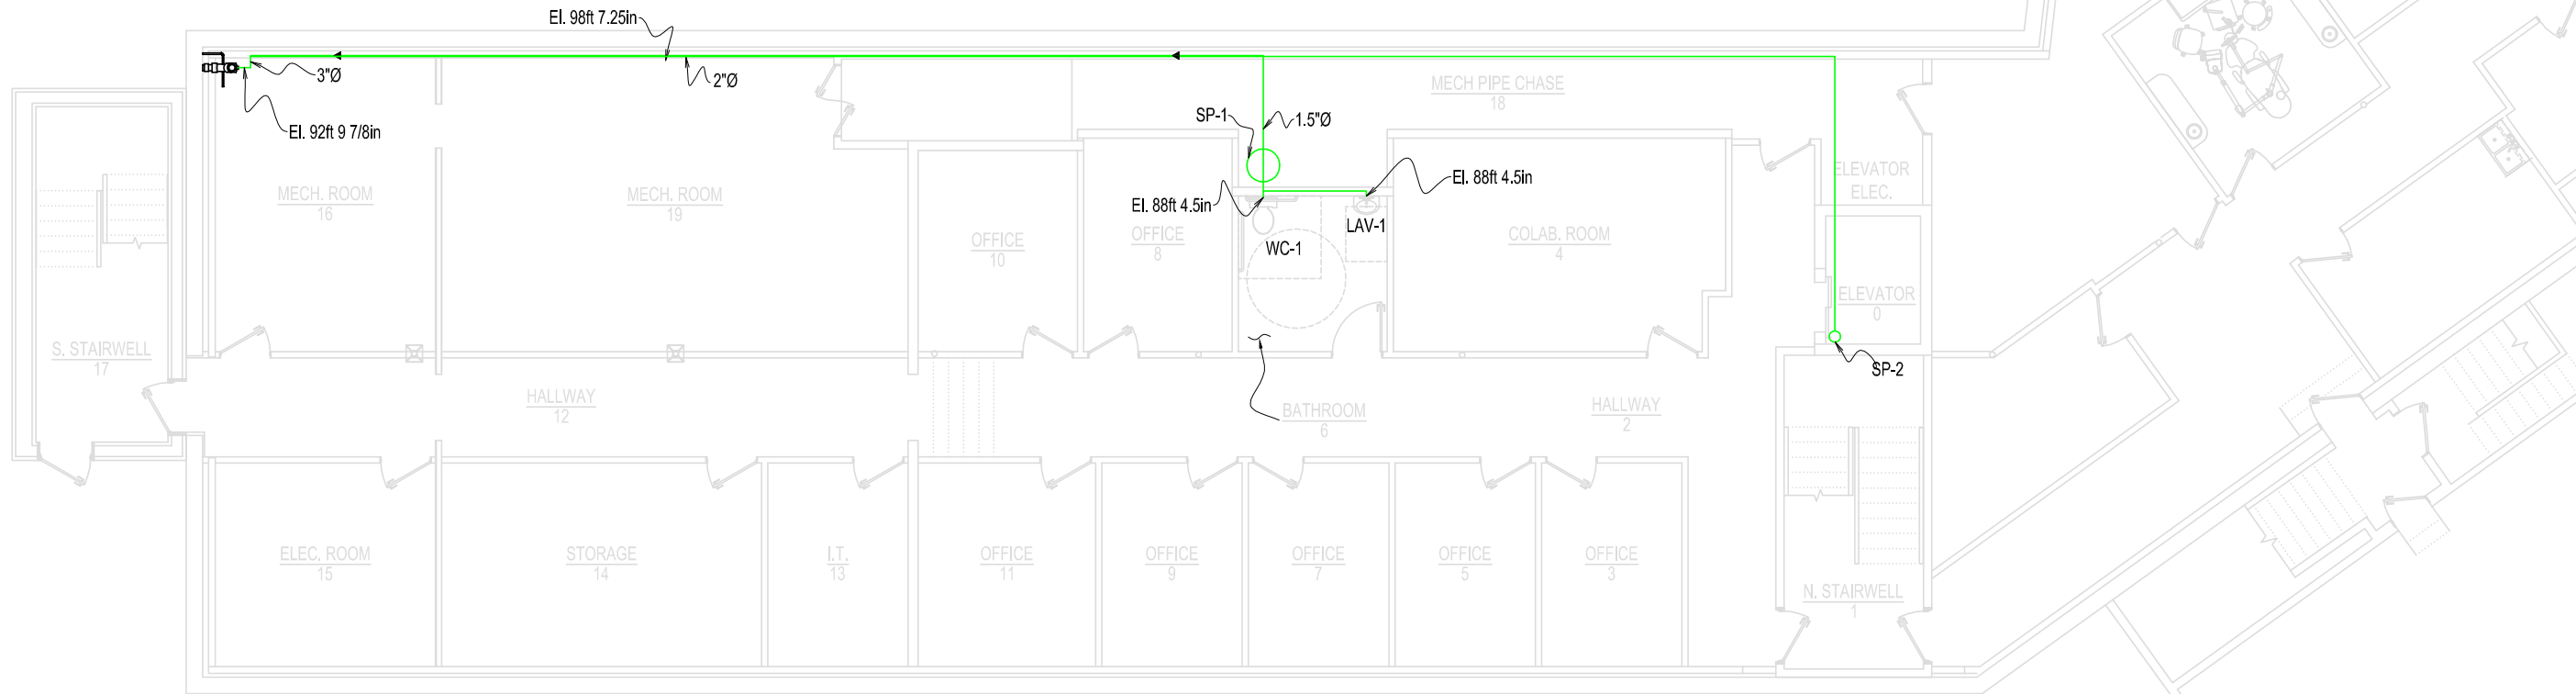

- NOTES:
- 1) ALL HORIZONTAL VENT PIPE 2" DIA.
 - 2) 1.5" V DENOTES VERTICAL 1.5 INCH CONNECTION TO SEPTIC
 - 3) 3" VTR DENOTES 3 INCH VERTICAL-THROUGH-ROOF CONNECTION
 - 4) ALL VENT PIPING SHALL BE SCH 40 PVC DWV PER ASTM D1665
 - 5) INSTALL ALL HORIZONTAL VENT PIPING TO SLOPE TOWARD THE PIPE IT SERVES.

HEALTH CENTER BASEMENT SANITARY PIPING PLAN
SCALE: 3/32 IN. = 1 FT.

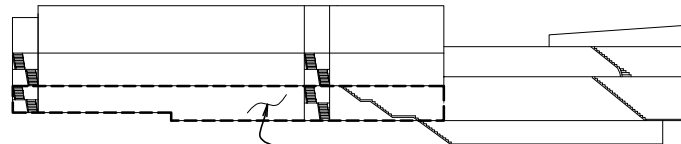

ELEVATION KEY


FOR CONSTRUCTION
REV 0/08


HEALTH CENTER BASEMENT SANITARY PIPING PLAN
ST. CROIX HEALTH CENTER
MAIN STREET
CALAIS, MAINE

DATE: 09/22/26
SCALE: NOTED
DRAWN: LW
JOB NO: 26001P
P2

THIS DRAWING IS AN INSTRUMENT
DESIGNED TO FACILITATE THE WORK
UNDER THE JOB NUMBER INDICATED.
IT IS THE PROPERTY OF FORESIGHT
ENGINEERING AND IS NOT TO BE USED
FOR OTHER WORK ACCEPT BY
WRITTEN AGREEMENT WITH
FORESIGHT ENGINEERING.


FORESIGHT ENGINEERING P.C.
10 FLEMING STREET
LINCOLN, MAINE 04457
(207) 794-2775
(PHONE OR FAX)

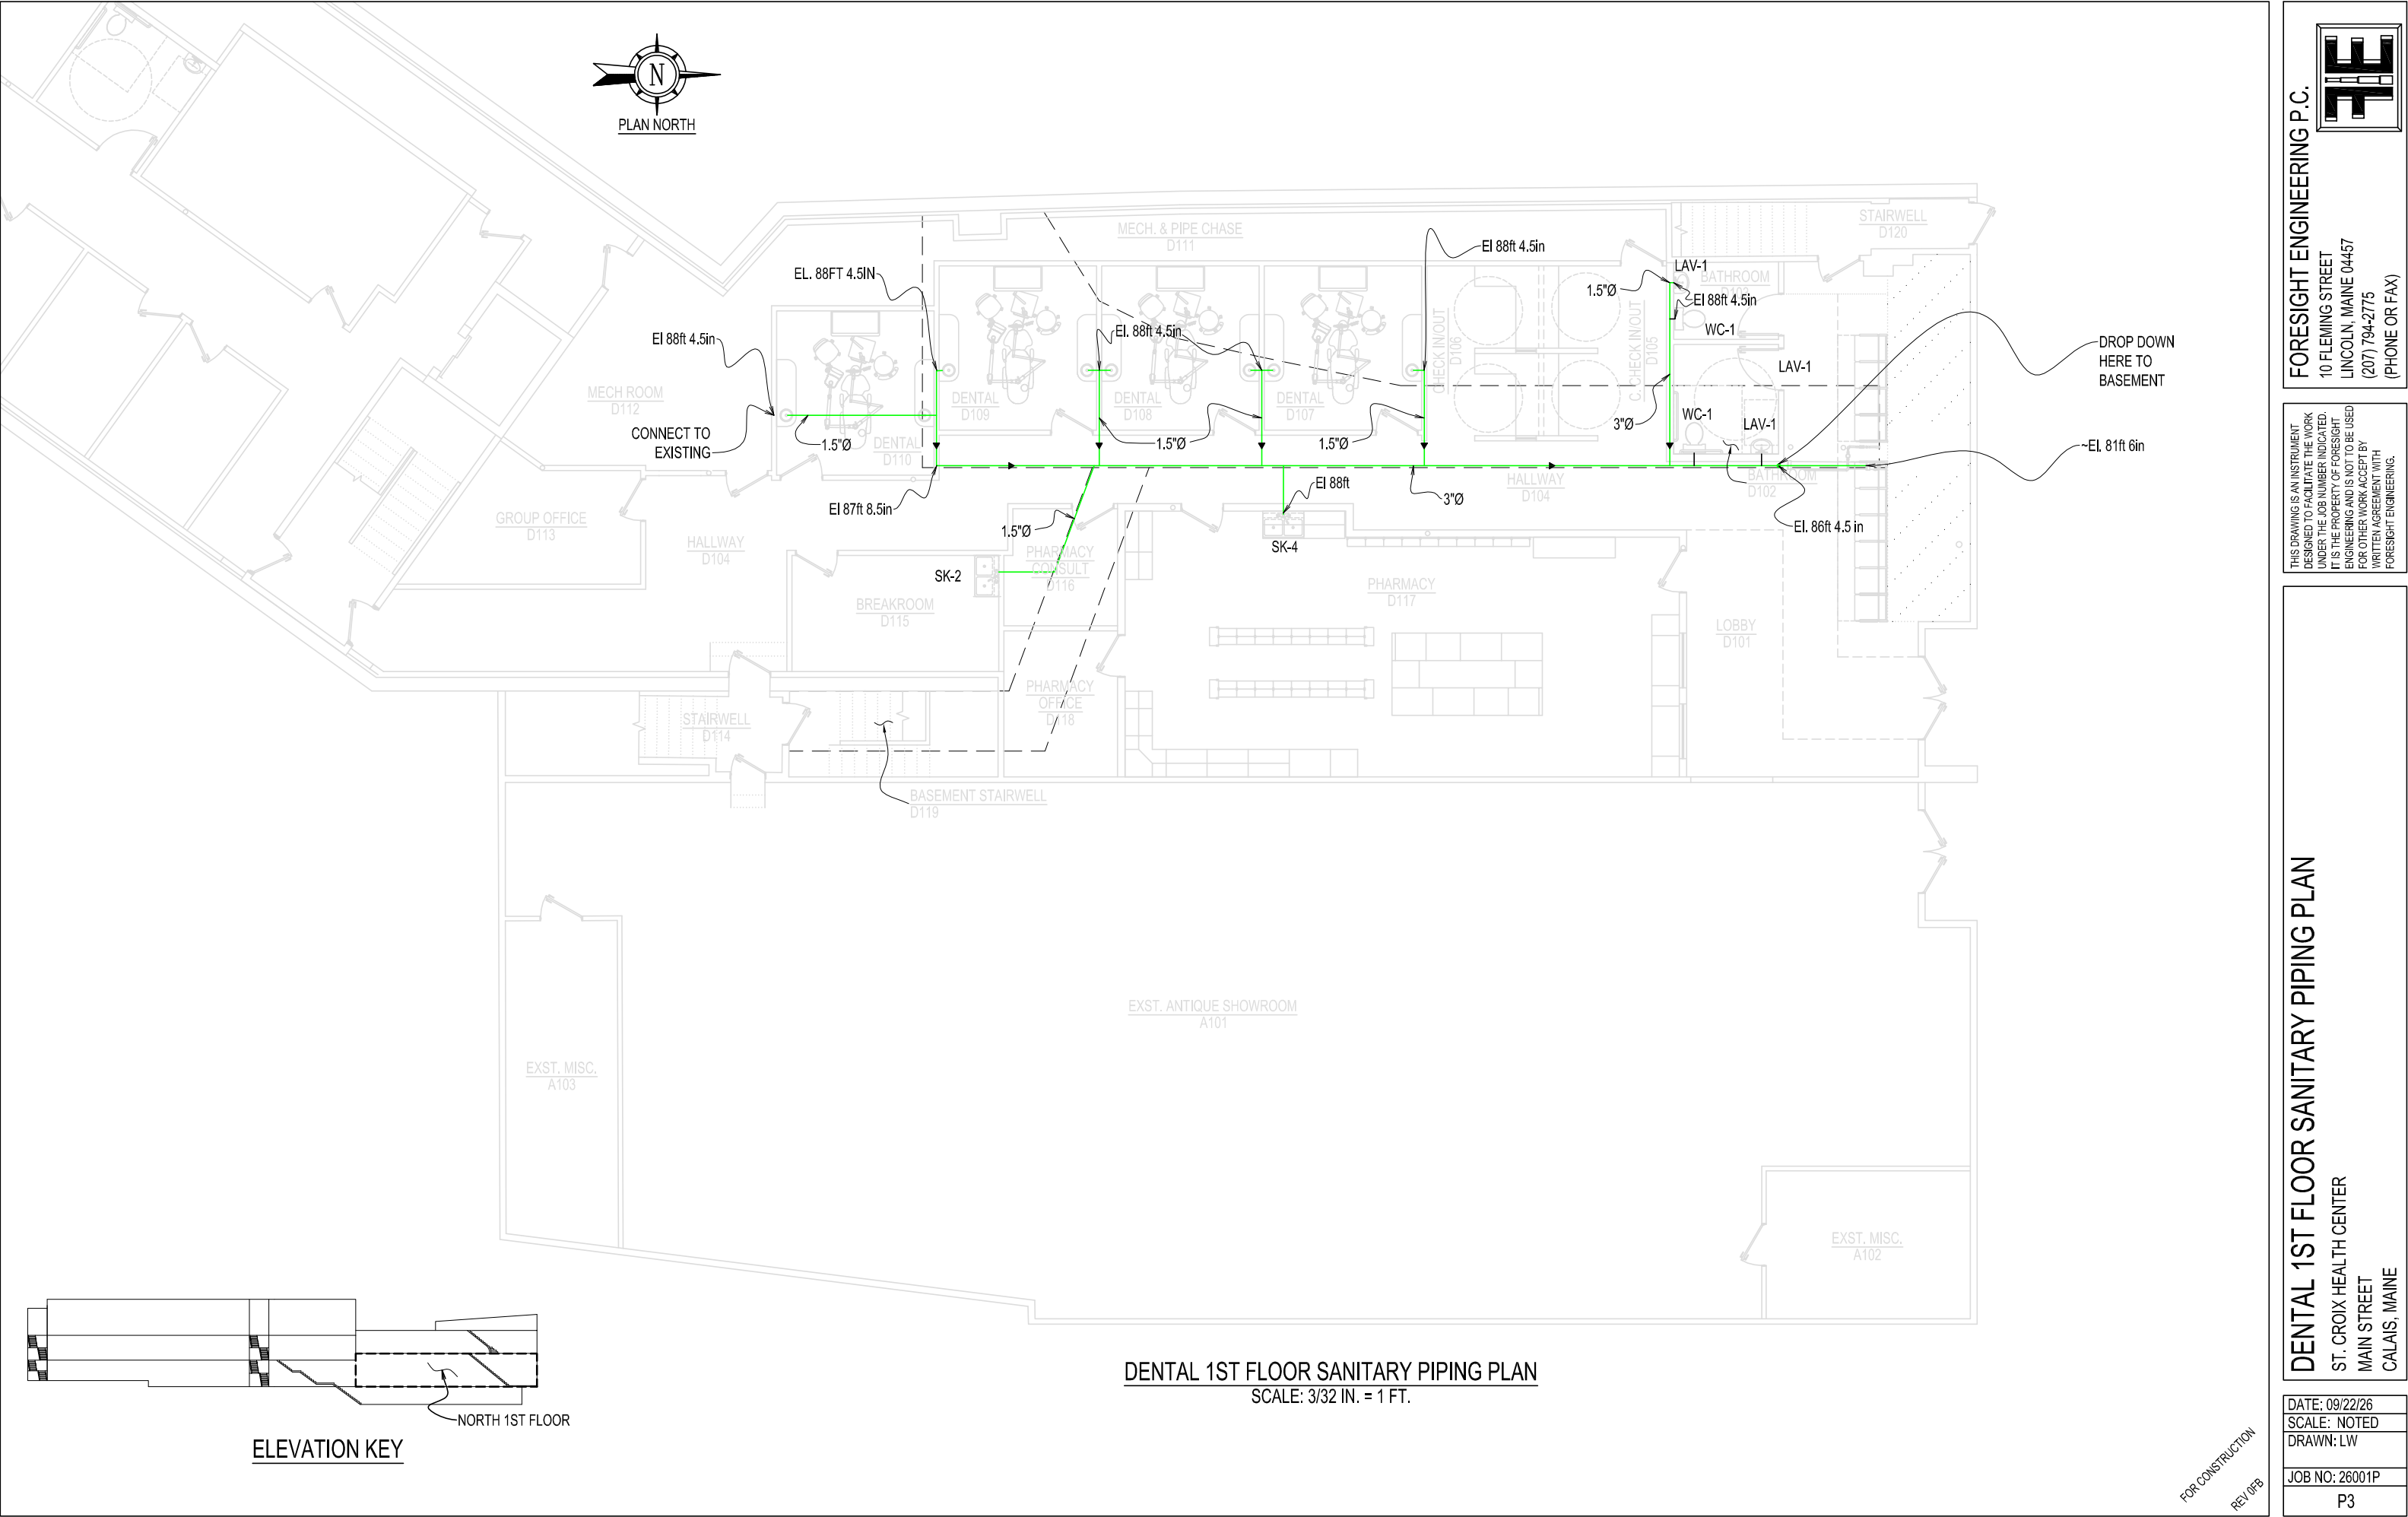

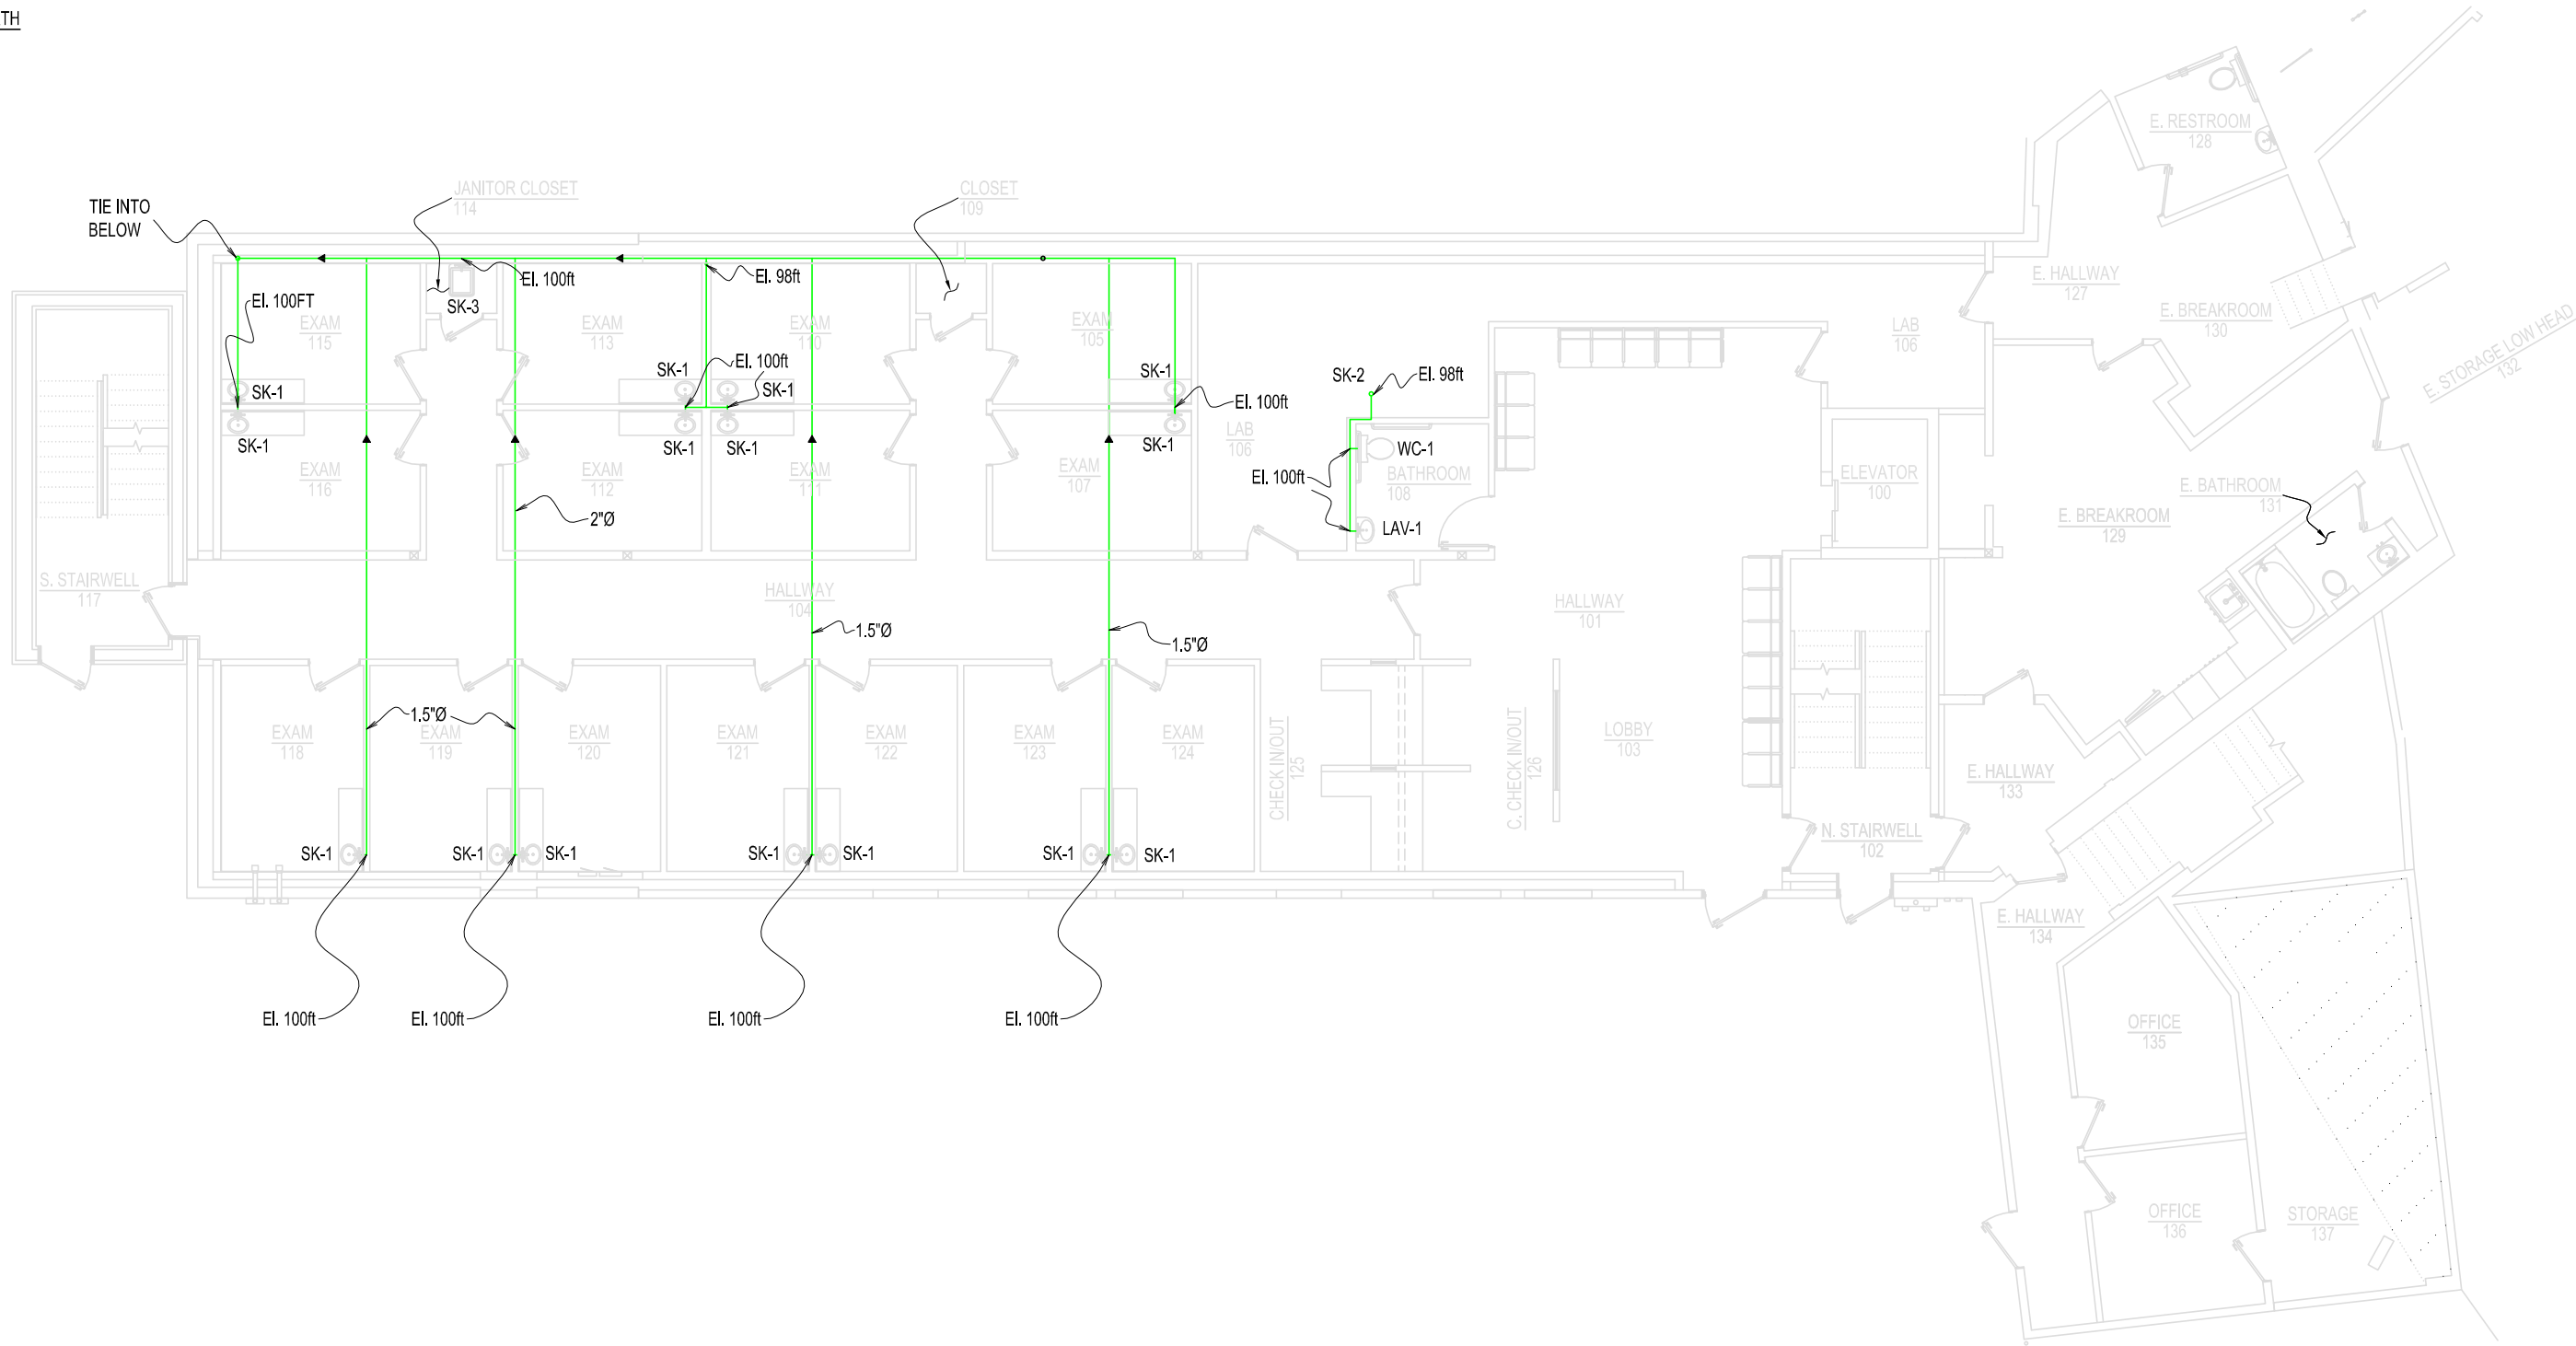

- NOTES:
- 1) ALL HORIZONTAL VENT PIPE 2" DIA.
 - 2) 1.5" V DENOTES VERTICAL 1.5 INCH CONNECTION TO SEPTIC
 - 3) 3" VTR DENOTES 3 INCH VERTICAL-THROUGH-ROOF CONNECTION
 - 4) ALL VENT PIPING SHALL BE SCH 40 PVC DWV PER ASTM D1665
 - 5) INSTALL ALL HORIZONTAL VENT PIPING TO SLOPE TOWARD THE PIPE IT SERVES.

HEALTH CENTER 1ST FLOOR SANITARY PIPING PLAN
SCALE: 3/32 IN. = 1 FT.

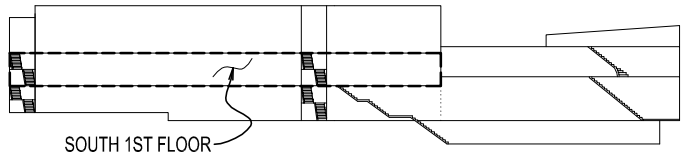

ELEVATION KEY


FOR CONSTRUCTION
REV 0/08

HEALTH CENTER 1ST FLOOR SANITARY PIPING PLAN
ST. CROIX HEALTH CENTER
MAIN STREET
CALAIS, MAINE

DATE: 09/22/26
SCALE: NOTED
DRAWN: LW
JOB NO: 26001P
P4


THIS DRAWING IS AN INSTRUMENT
DESIGNED TO FACILITATE THE WORK
UNDER THE JOB NUMBER INDICATED.
IT IS THE PROPERTY OF FORESIGHT
ENGINEERING AND IS NOT TO BE USED
FOR OTHER WORK ACCEPT BY
WRITTEN AGREEMENT WITH
FORESIGHT ENGINEERING.

FORESIGHT ENGINEERING P.C.
10 FLEMING STREET
LINCOLN, MAINE 04457
(207) 794-2775
(PHONE OR FAX)

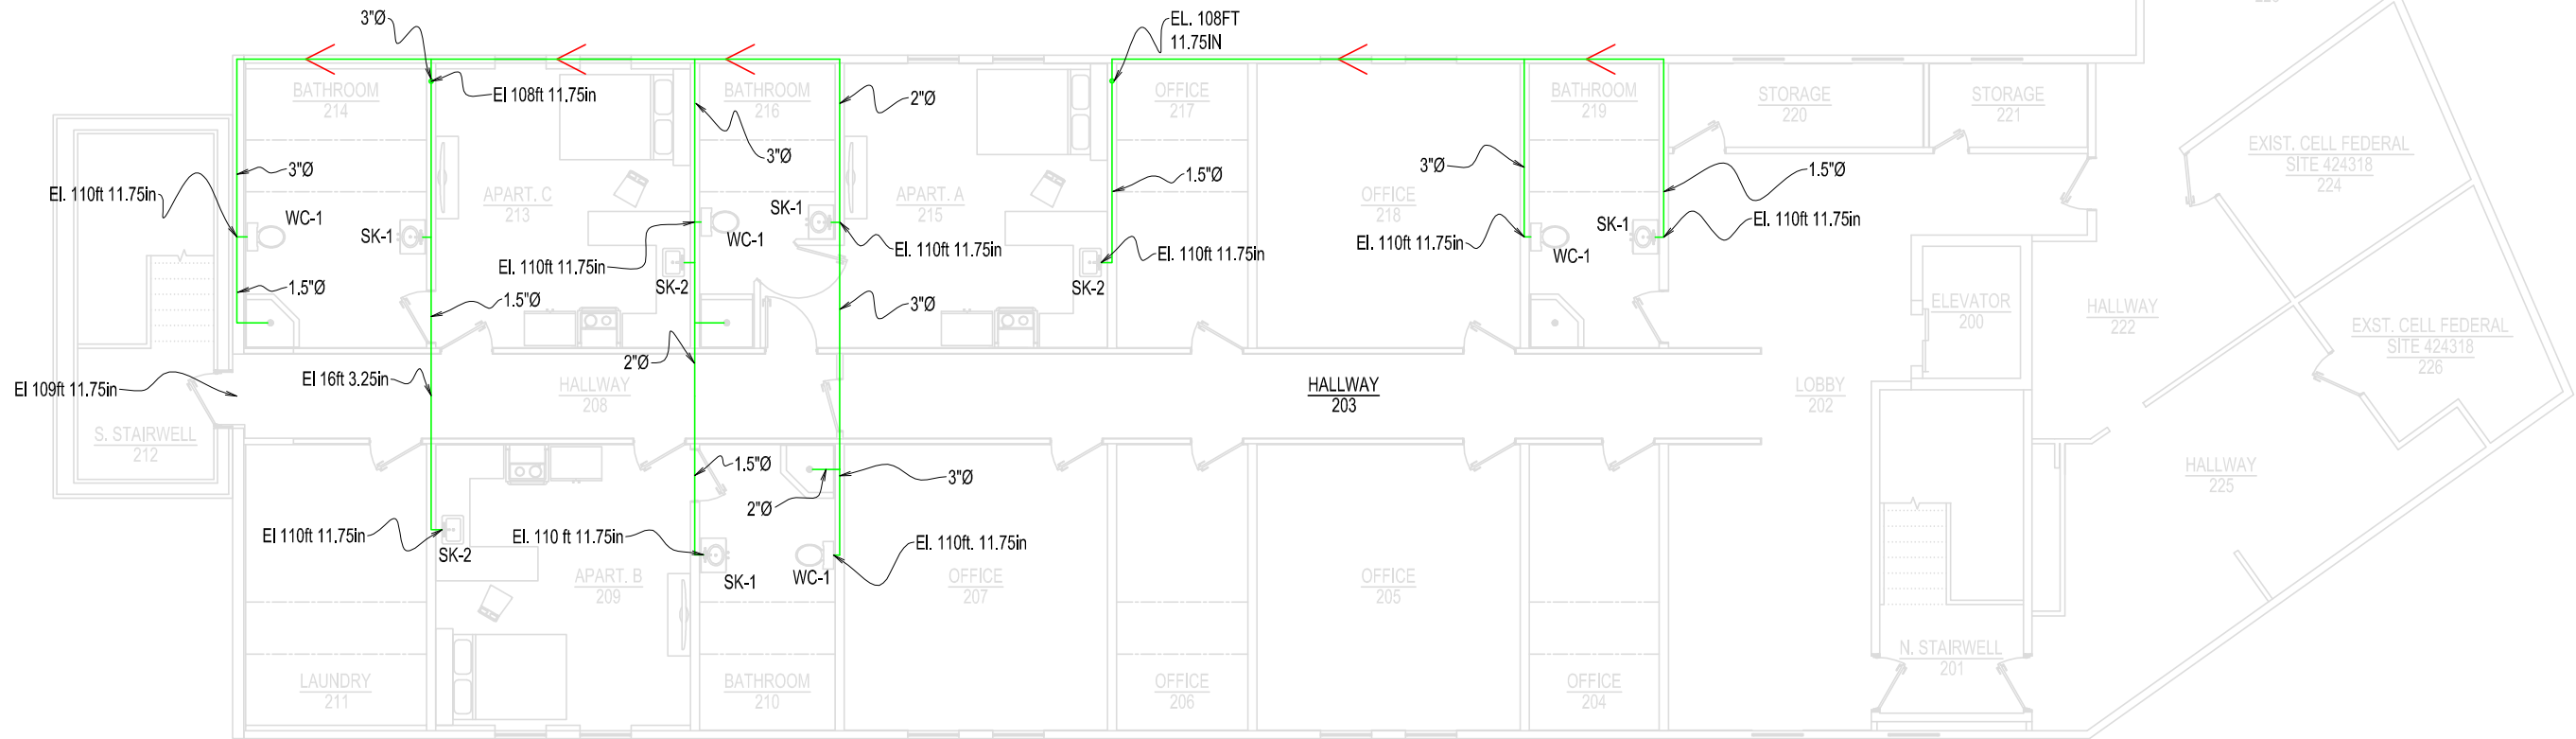

- NOTES:
- 1) ALL HORIZONTAL VENT PIPE 2" DIA.
 - 2) 1.5" V DENOTES VERTICAL 1.5 INCH CONNECTION TO SEPTIC
 - 3) 3" VTR DENOTES 3 INCH VERTICAL-THROUGH-ROOF CONNECTION
 - 4) ALL VENT PIPING SHALL BE SCH 40 PVC DWV PER ASTM D1665
 - 5) INSTALL ALL HORIZONTAL VENT PIPING TO SLOPE TOWARD THE PIPE IT SERVES.

APARTMENTS 2ND FLOOR SANITARY PIPING PLAN
SCALE: 3/32 IN. = 1 FT.

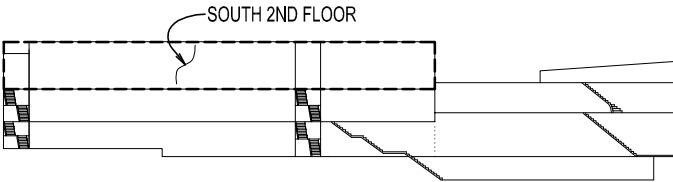

ELEVATION KEY

FOR CONSTRUCTION
REV 0/05

FORESIGHT ENGINEERING P.C.
10 FLEMING STREET
LINCOLN, MAINE 04457
(207) 794-2775
(PHONE OR FAX)

THIS DRAWING IS AN INSTRUMENT
DESIGNED TO FACILITATE THE WORK
UNDER THE JOB NUMBER INDICATED.
IT IS THE PROPERTY OF FORESIGHT
ENGINEERING AND IS NOT TO BE USED
FOR OTHER WORK ACCEPT BY
WRITTEN AGREEMENT WITH
FORESIGHT ENGINEERING.


APARTMENTS 2ND FLOOR SANITARY PIPING PLAN
ST. CROIX HEALTH CENTER
MAIN STREET
CALAIS, MAINE

DATE: 09/22/26
SCALE: NOTED
DRAWN: LW
JOB NO: 26001P
P6

NOTES:

- 1) ALL HORIZONTAL VENT PIPE 2" DIA.
- 2) 1.5" V DENOTES VERTICAL 1.5 INCH CONNECTION TO SEPTIC
- 3) 3" VTR DENOTES 3 INCH VERTICAL-THROUGH-ROOF CONNECTION
- 4) ALL VENT PIPING SHALL BE SCH 40 PVC DWV PER ASTM D1665
- 5) INSTALL ALL HORIZONTAL VENT PIPING TO SLOPE TOWARD THE PIPE IT SERVES.

HEALTH CENTER BASEMENT WATER SUPPLY PLAN
SCALE: 3/32 IN. = 1 FT.

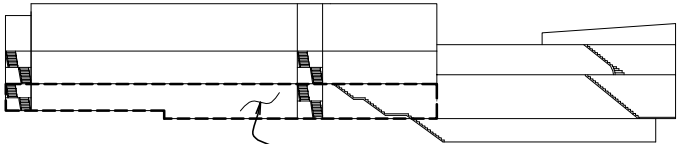

SOUTH BASEMENT

ELEVATION KEY

FOR CONSTRUCTION
REV 0/08

HEALTH CENTER BASEMENT WATER SUPPLY PLAN

ST. CROIX HEALTH CENTER
MAIN STREET
CALAIS, MAINE

DATE: 09/22/26
SCALE: NOTED
DRAWN: LW


JOB NO: 26001P
P7

THIS DRAWING IS AN INSTRUMENT
DESIGNED TO FACILITATE THE WORK
UNDER THE JOB NUMBER INDICATED.
IT IS THE PROPERTY OF FORESIGHT
ENGINEERING AND IS NOT TO BE USED
FOR OTHER WORK ACCEPT BY
WRITTEN AGREEMENT WITH
FORESIGHT ENGINEERING.

FORESIGHT ENGINEERING P.C.

10 FLEMING STREET
LINCOLN, MAINE 04457
(207) 794-2775
(PHONE OR FAX)



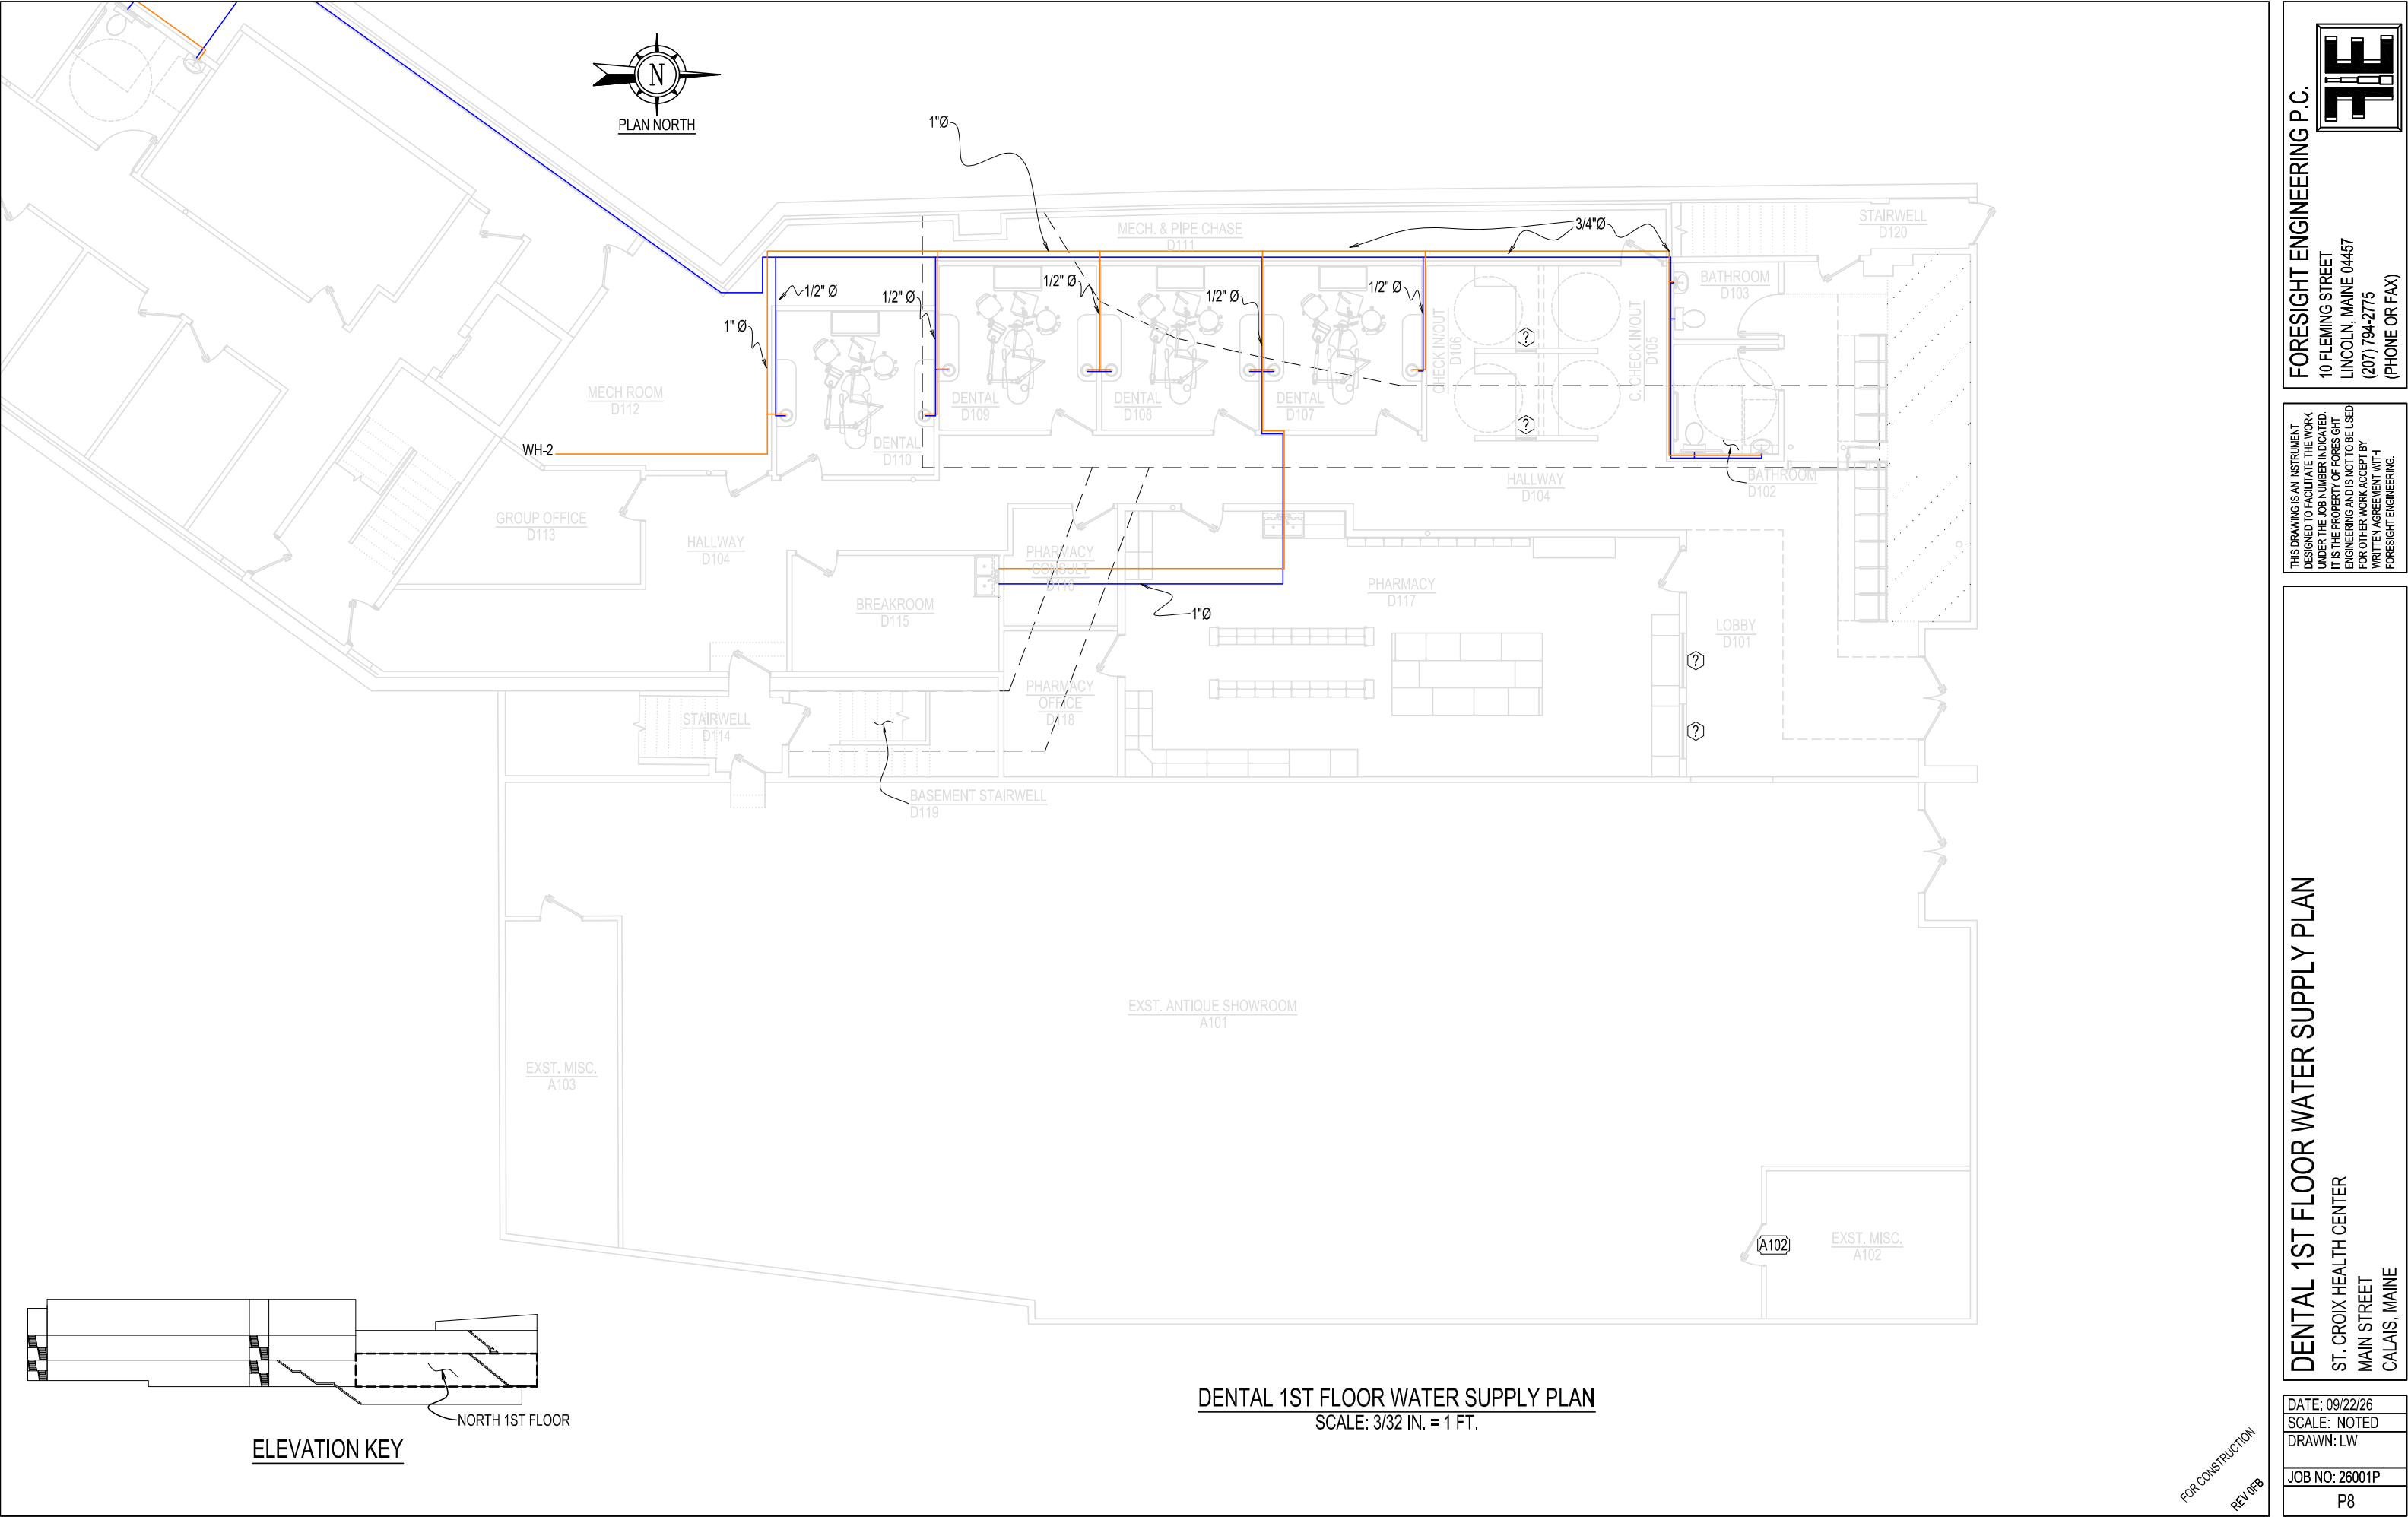

FOR CONSTRUCTION
REV 0/08


DATE: 09/22/26
SCALE: NOTED
DRAWN: LW

JOB NO: 26001P
P8

DENTAL 1ST FLOOR WATER SUPPLY PLAN
ST. CROIX HEALTH CENTER
MAIN STREET
CALAIS, MAINE


THIS DRAWING IS AN INSTRUMENT
DESIGNED TO FACILITATE THE WORK
UNDER THE JOB NUMBER INDICATED.
IT IS THE PROPERTY OF FORESIGHT
ENGINEERING AND IS NOT TO BE USED
FOR OTHER WORK ACCEPT BY
WRITTEN AGREEMENT WITH
FORESIGHT ENGINEERING.

FORESIGHT ENGINEERING P.C.
10 FLEMING STREET
LINCOLN, MAINE 04457
(207) 794-2775
(PHONE OR FAX)

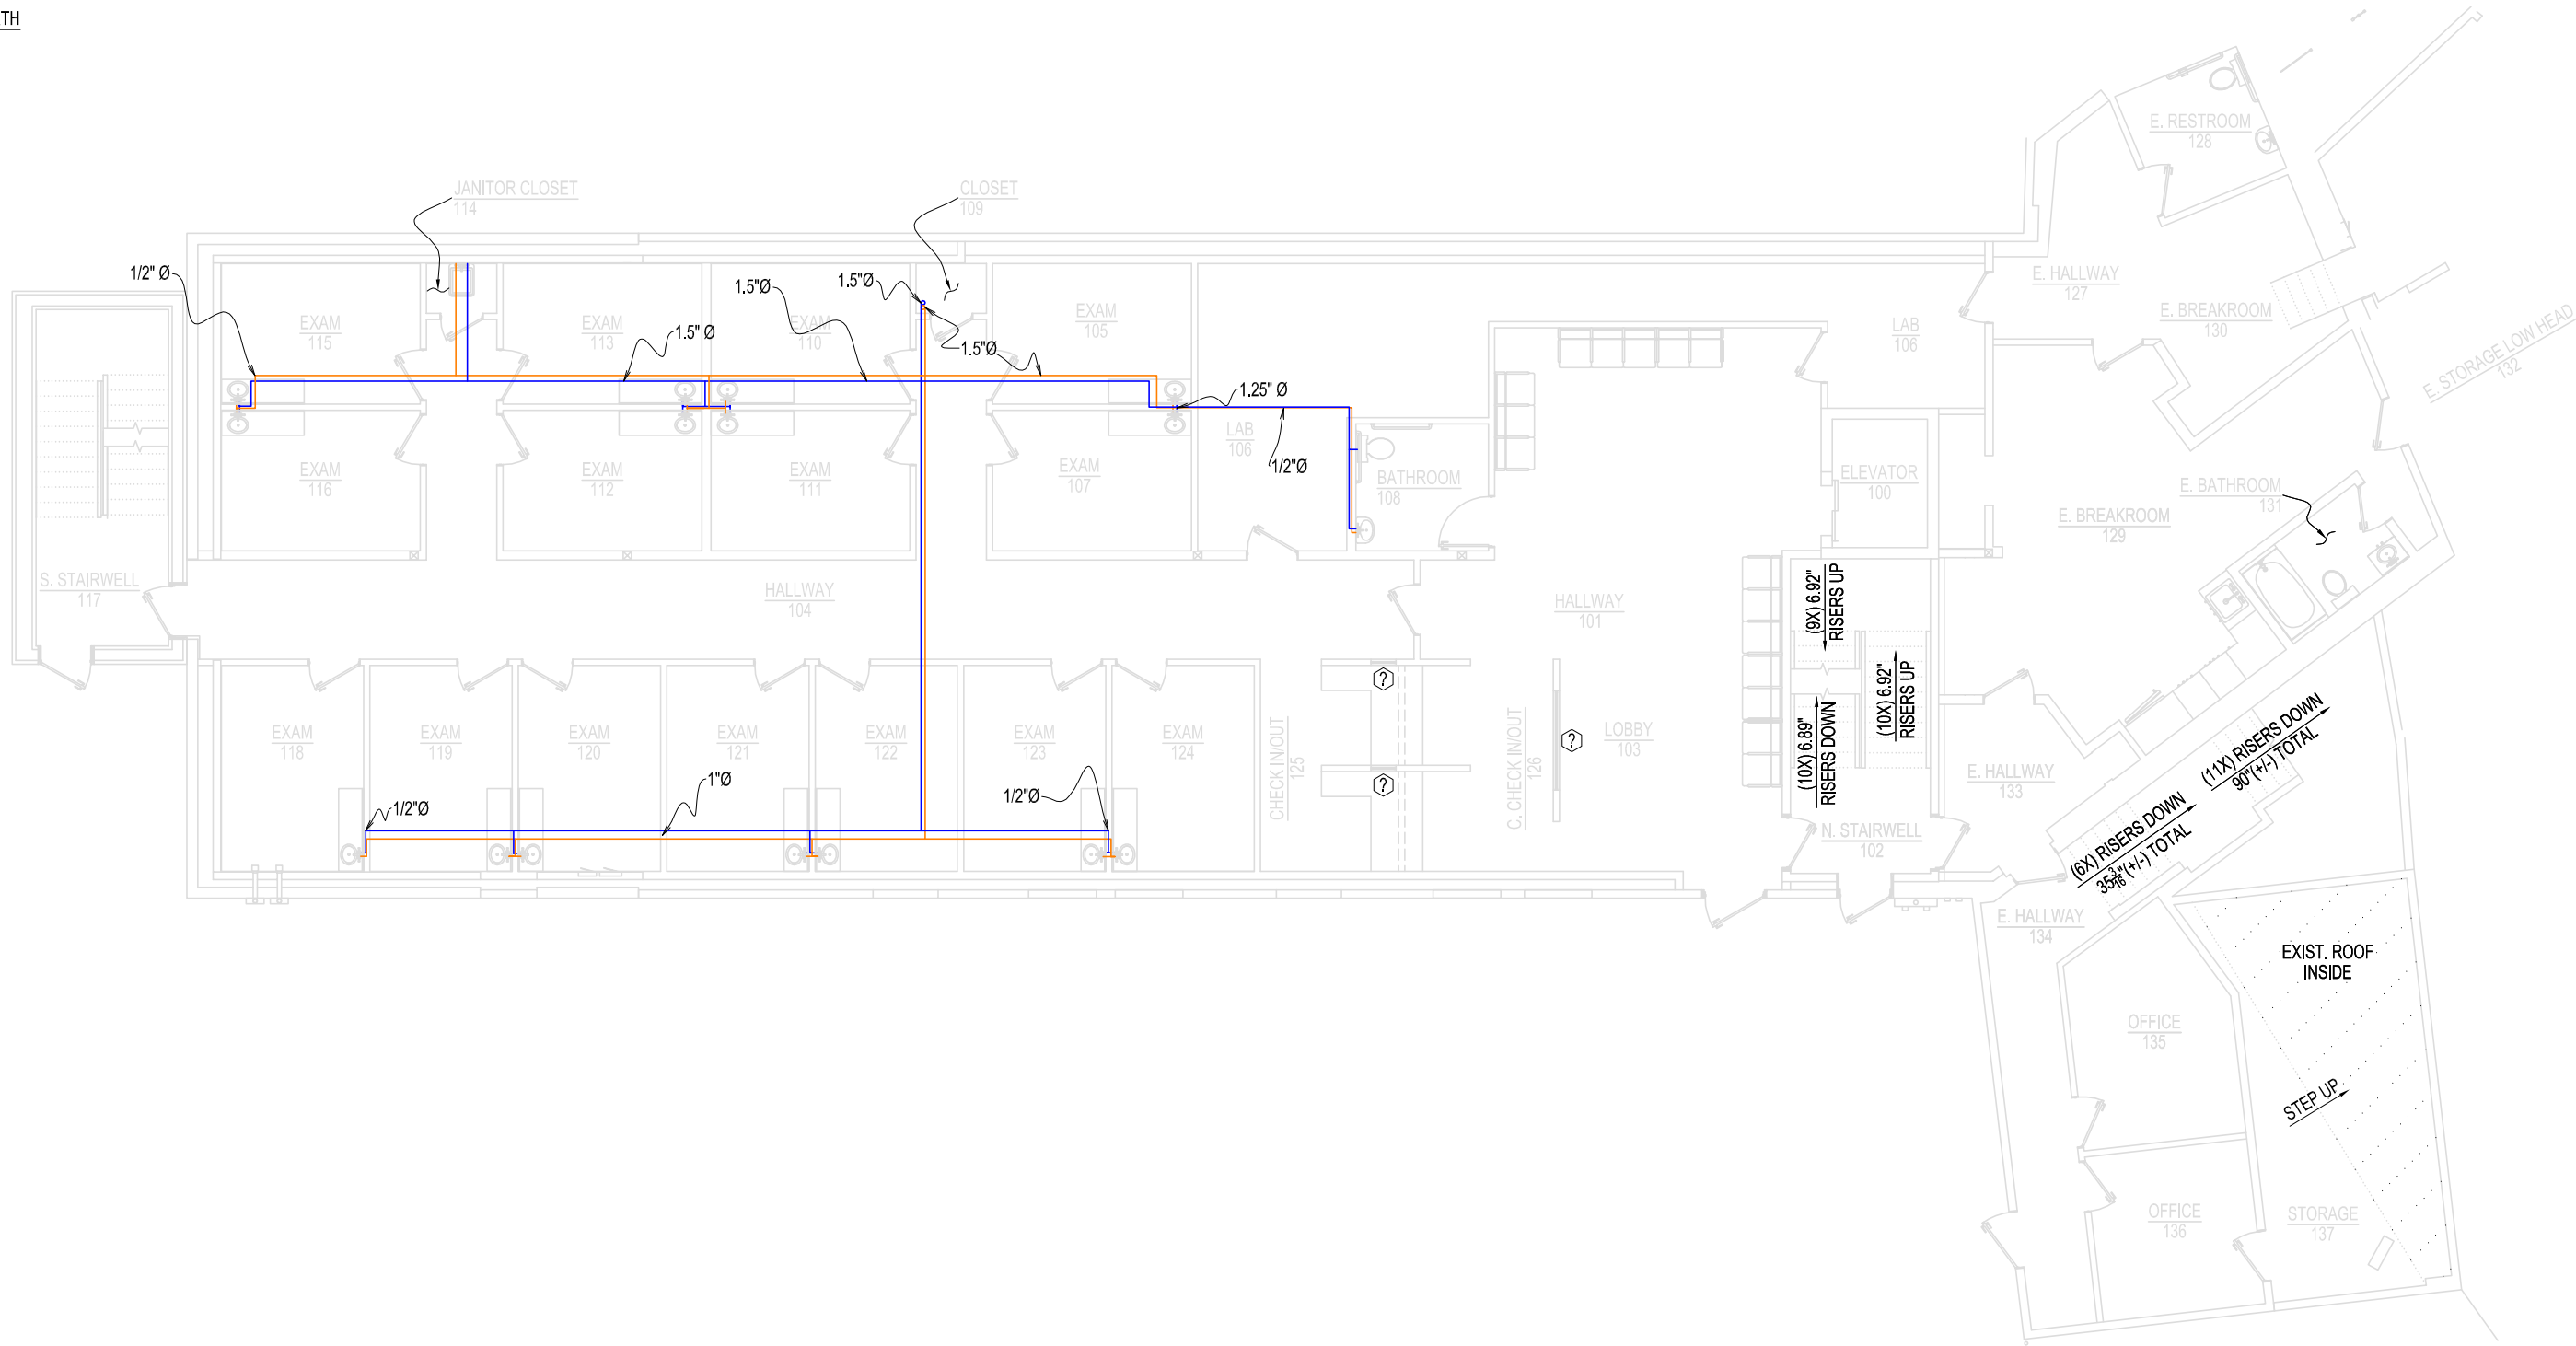

- NOTES:
- 1) ALL HORIZONTAL VENT PIPE 2" DIA.
 - 2) 1.5" V DENOTES VERTICAL 1.5 INCH CONNECTION TO SEPTIC
 - 3) 3" VTR DENOTES 3 INCH VERTICAL-THROUGH-ROOF CONNECTION
 - 4) ALL VENT PIPING SHALL BE SCH 40 PVC DWV PER ASTM D1665
 - 5) INSTALL ALL HORIZONTAL VENT PIPING TO SLOPE TOWARD THE PIPE IT SERVES.

HEALTH CENTER 1ST FLOOR WATER SUPPLY PLAN
SCALE: 3/32 IN. = 1 FT.

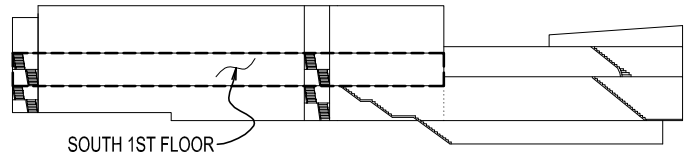

ELEVATION KEY

FOR CONSTRUCTION
REV 0/08

FORESIGHT ENGINEERING P.C.

10 FLEMING STREET
LINCOLN, MAINE 04457
(207) 794-2775
(PHONE OR FAX)


THIS DRAWING IS AN INSTRUMENT
DESIGNED TO FACILITATE THE WORK
UNDER THE JOB NUMBER INDICATED.
IT IS THE PROPERTY OF FORESIGHT
ENGINEERING AND IS NOT TO BE USED
FOR OTHER WORK ACCEPT BY
WRITTEN AGREEMENT WITH
FORESIGHT ENGINEERING.

HEALTH CENTER 1ST FLOOR WATER SUPPLY PLAN


ST. CROIX HEALTH CENTER
MAIN STREET
CALAIS, MAINE

DATE: 09/22/26
SCALE: NOTED
DRAWN: LW

JOB NO: 26001P
P9

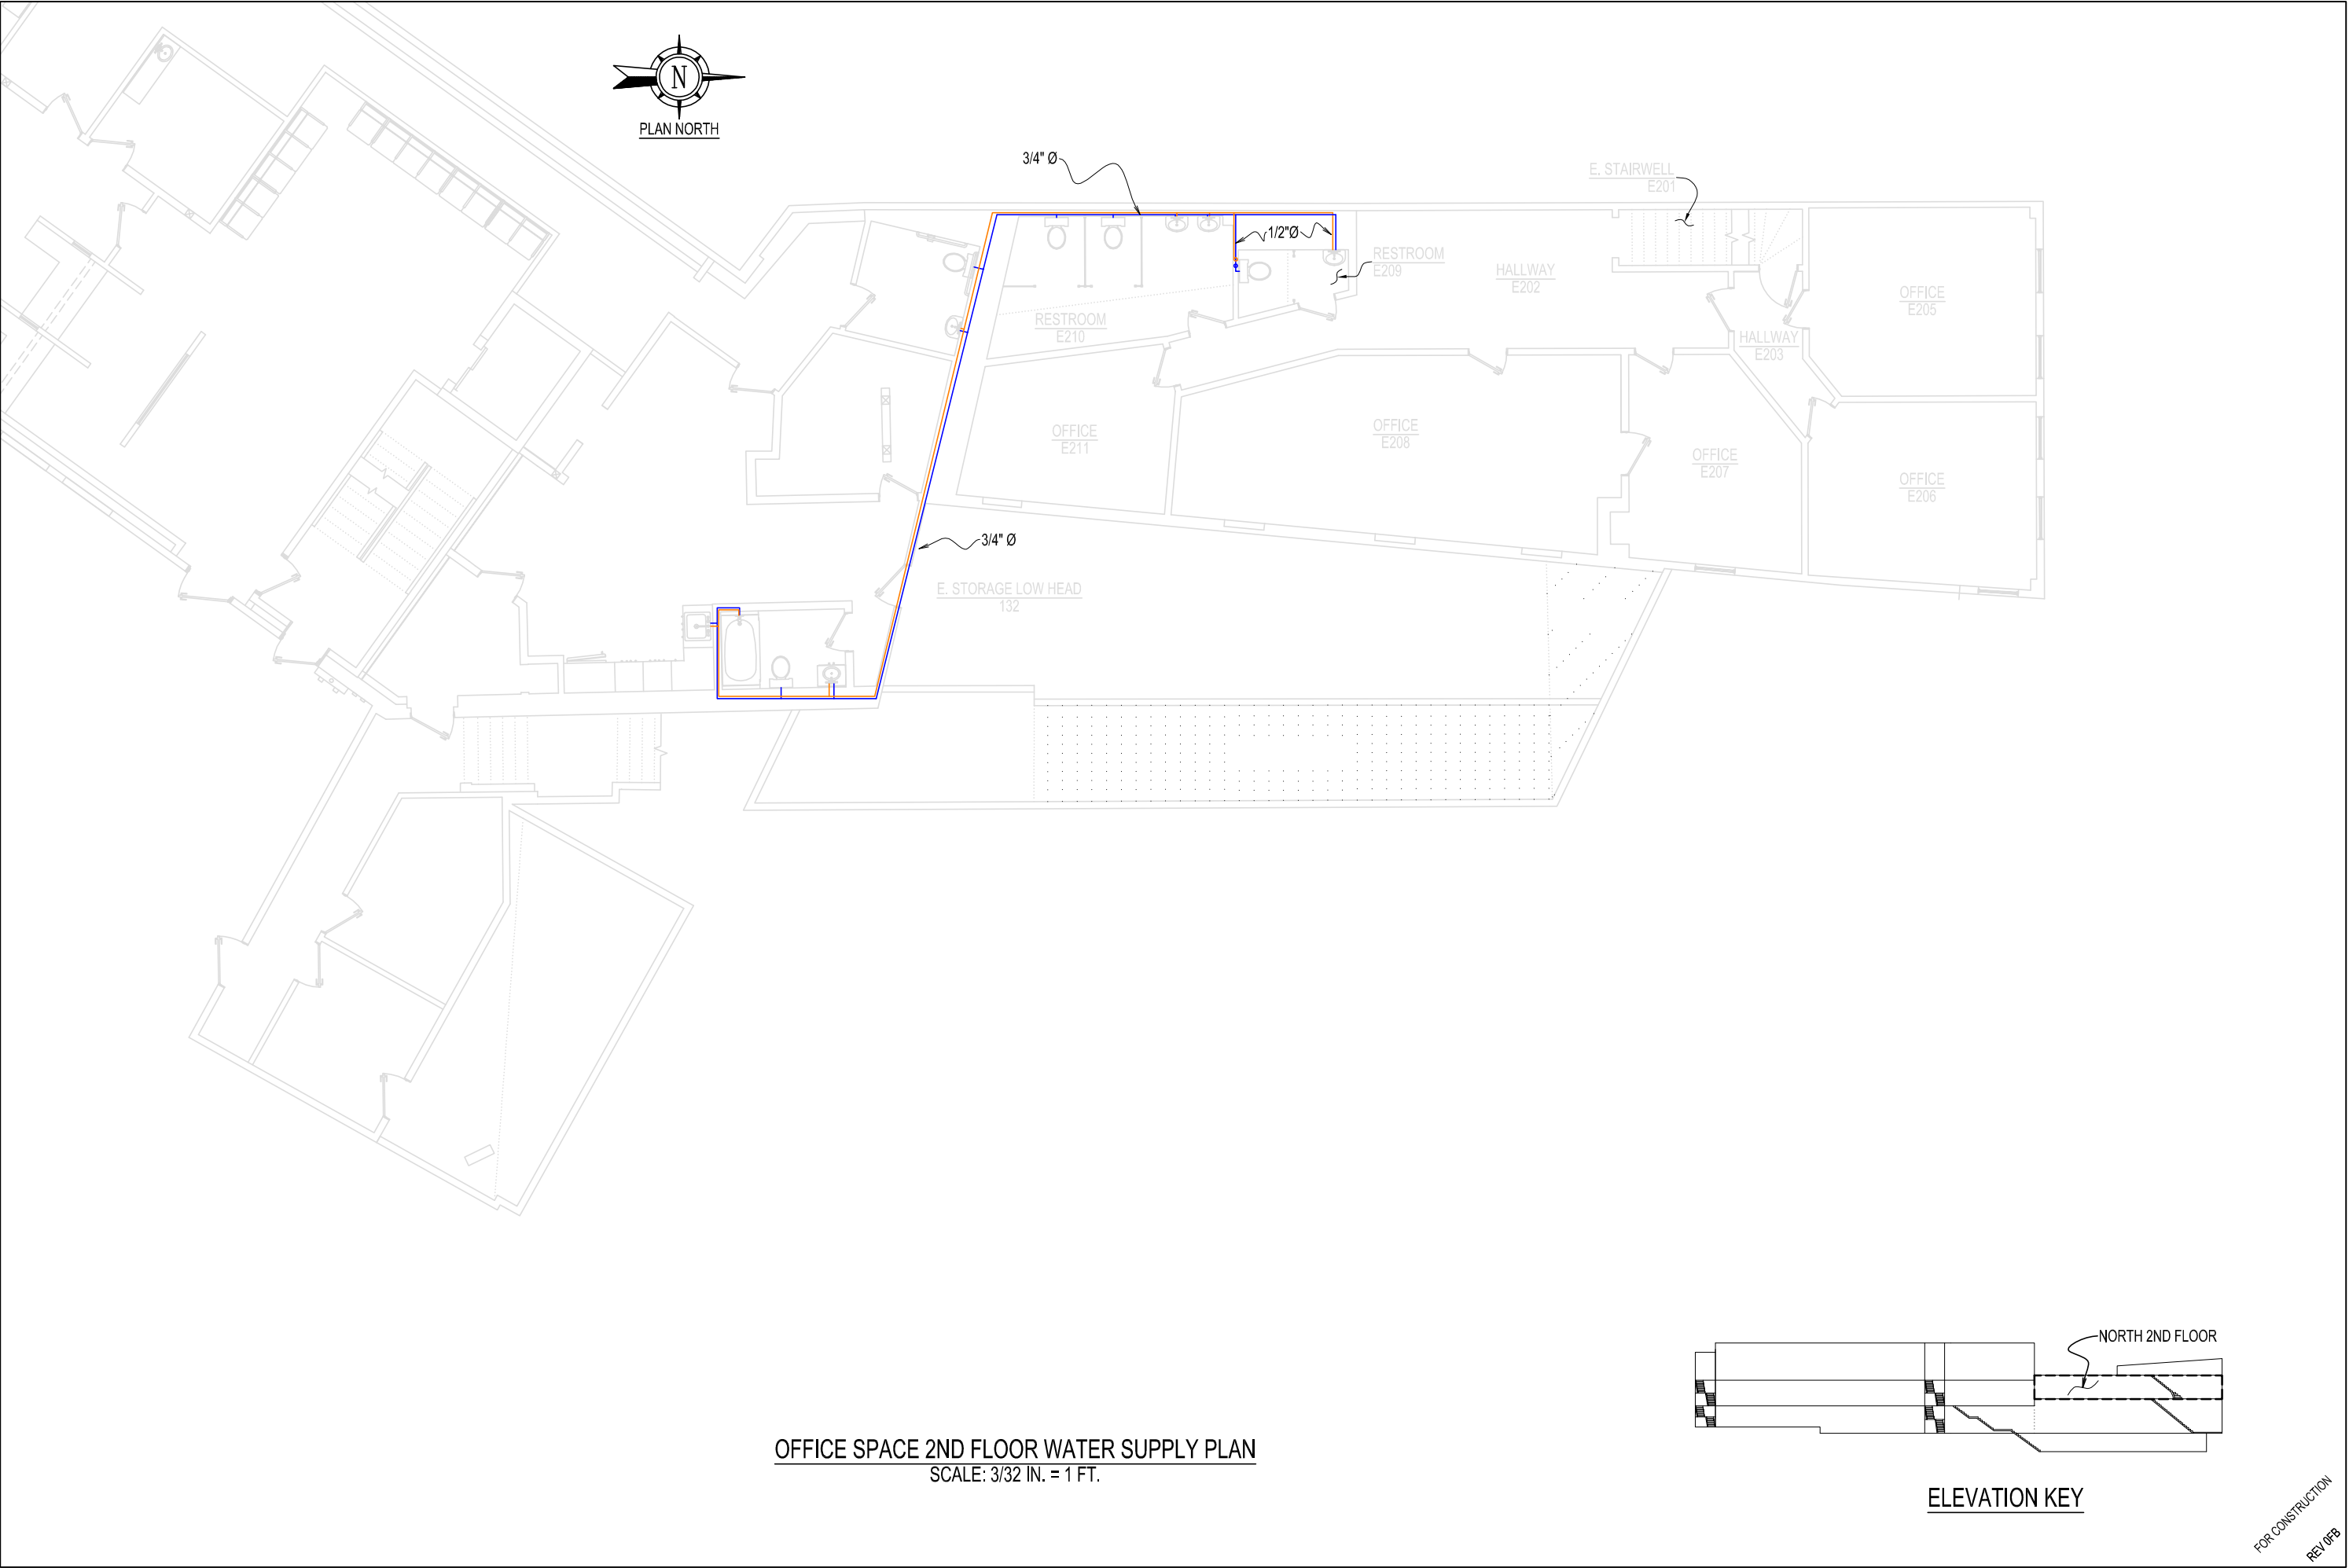

OFFICE SPACE 2ND FLOOR WATER SUPPLY PLAN
SCALE: 3/32 IN. = 1 FT.

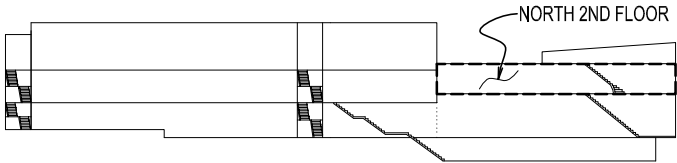

ELEVATION KEY

FOR SIGHT ENGINEERING P.C.

10 FLEMING STREET
LINCOLN, MAINE 04457
(207) 794-2775
(PHONE OR FAX)

THIS DRAWING IS AN INSTRUMENT
DESIGNED TO FACILITATE THE WORK
UNDER THE JOB NUMBER INDICATED.
IT IS THE PROPERTY OF FOR SIGHT
ENGINEERING AND IS NOT TO BE USED
FOR OTHER WORK ACCEPT BY
WRITTEN AGREEMENT WITH
FOR SIGHT ENGINEERING.


OFFICE SPACE 2ND FLOOR WATER SUPPLY PLAN

ST. CROIX HEALTH CENTER
MAIN STREET
CALAIS, MAINE

DATE: 09/22/26
SCALE: NOTED
DRAWN: LW


JOB NO: 26001P
P10

FOR CONSTRUCTION
REV 0/08

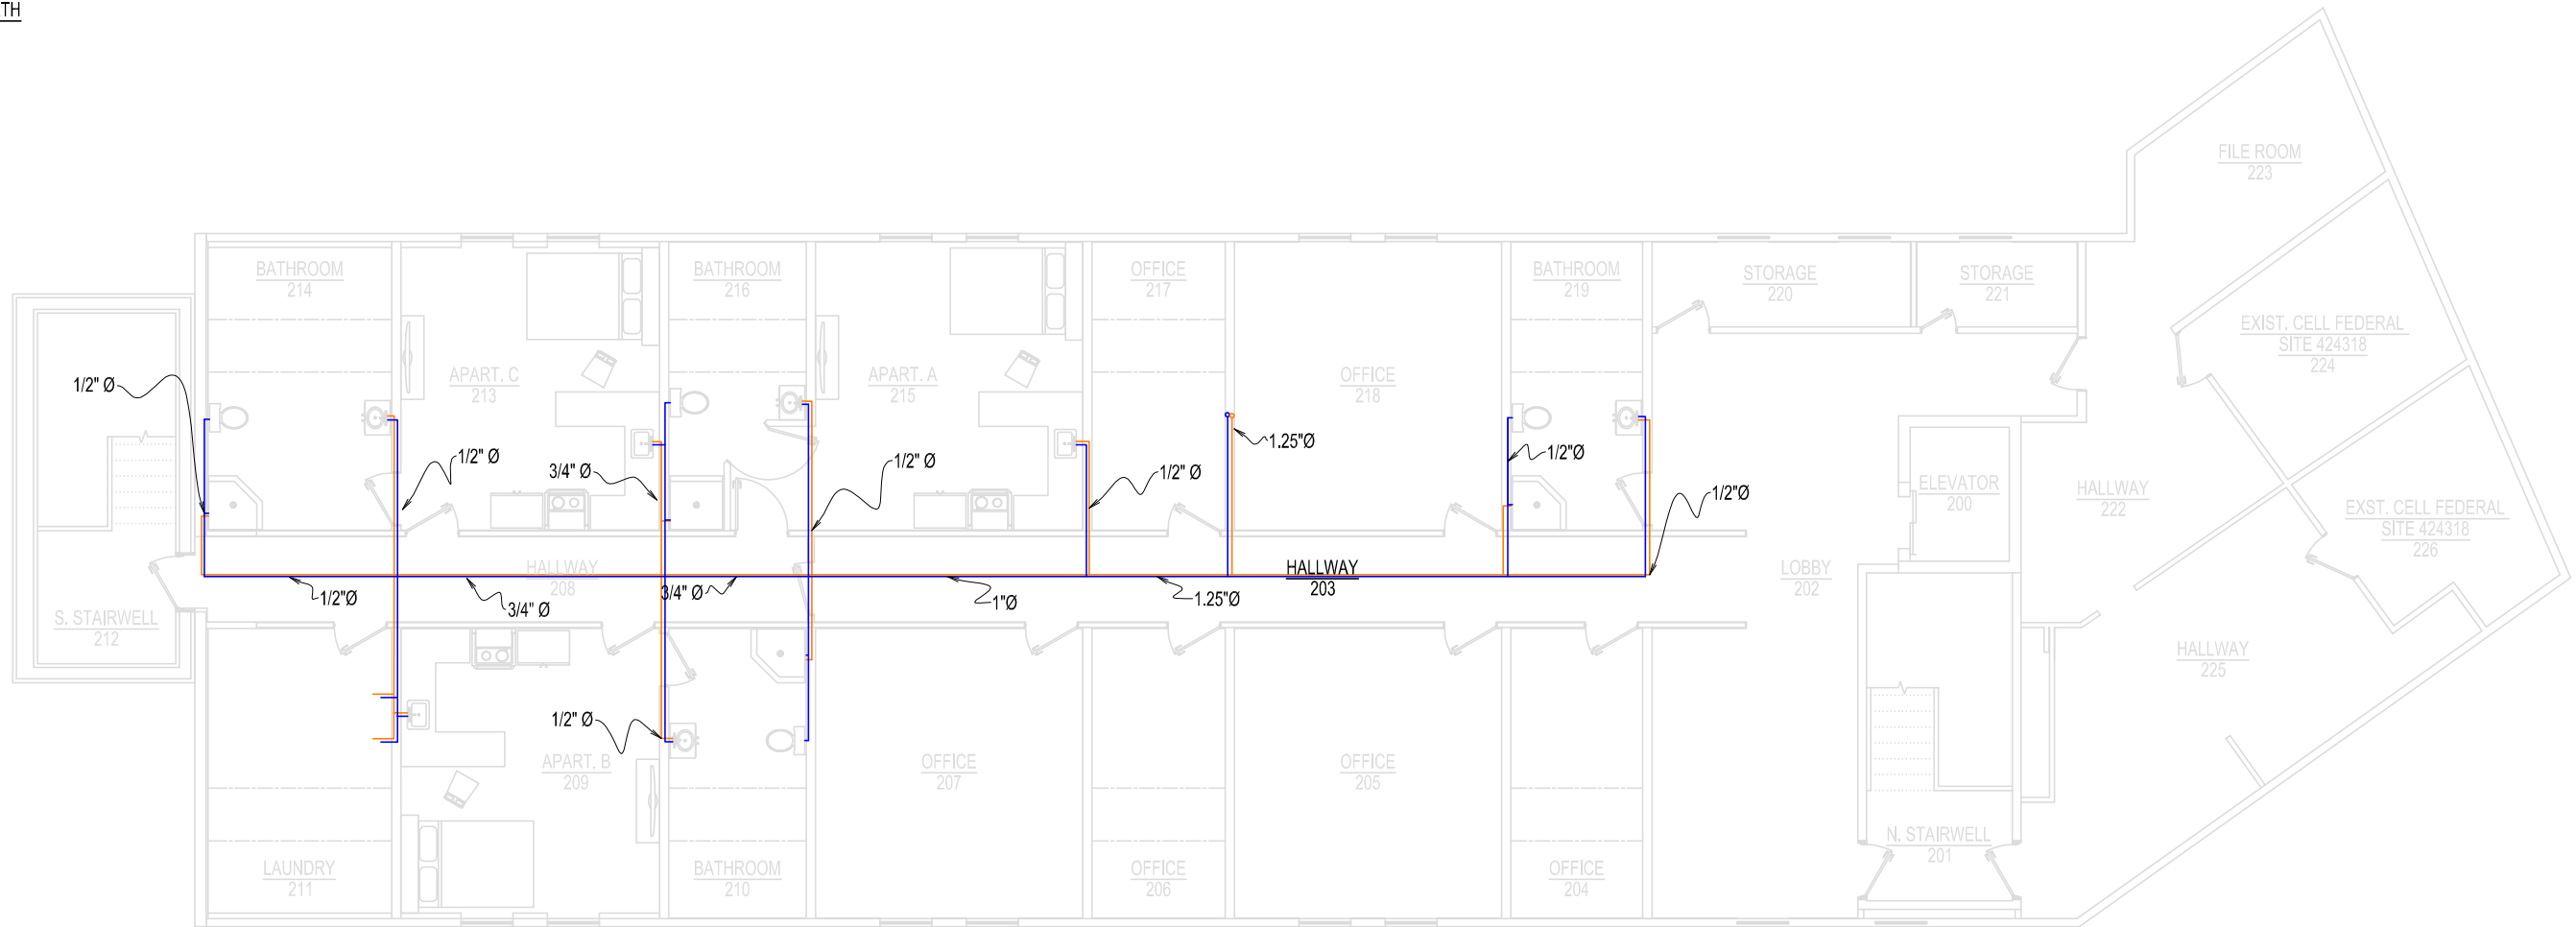

- NOTES:
- 1) ALL HORIZONTAL VENT PIPE 2" DIA.
 - 2) 1.5" V DENOTES VERTICAL 1.5 INCH CONNECTION TO SEPTIC
 - 3) 3" VTR DENOTES 3 INCH VERTICAL-THROUGH-ROOF CONNECTION
 - 4) ALL VENT PIPING SHALL BE SCH 40 PVC DWV PER ASTM D1665
 - 5) INSTALL ALL HORIZONTAL VENT PIPING TO SLOPE TOWARD THE PIPE IT SERVES.

APARTMENTS 2ND FLOOR WATER SUPPLY PLAN
SCALE: 3/32 IN. = 1 FT.

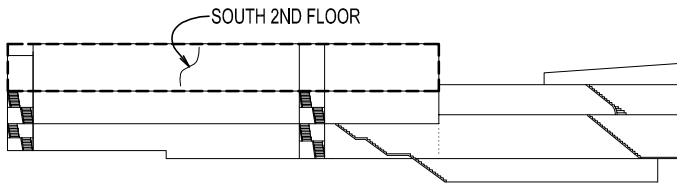

ELEVATION KEY

FOR CONSTRUCTION
REV 0/08


FORESIGHT ENGINEERING P.C.
10 FLEMING STREET
LINCOLN, MAINE 04457
(207) 794-2775
(PHONE OR FAX)

THIS DRAWING IS AN INSTRUMENT
DESIGNED TO FACILITATE THE WORK
UNDER THE JOB NUMBER INDICATED.
IT IS THE PROPERTY OF FORESIGHT
ENGINEERING AND IS NOT TO BE USED
FOR OTHER WORK ACCEPT BY
WRITTEN AGREEMENT WITH
FORESIGHT ENGINEERING.

APARTMENTS 2ND FLOOR WATER SUPPLY PLAN


ST. CROIX HEALTH CENTER
MAIN STREET
CALAIS, MAINE

DATE: 09/22/26
SCALE: NOTED
DRAWN: LW
JOB NO: 26001P
P11

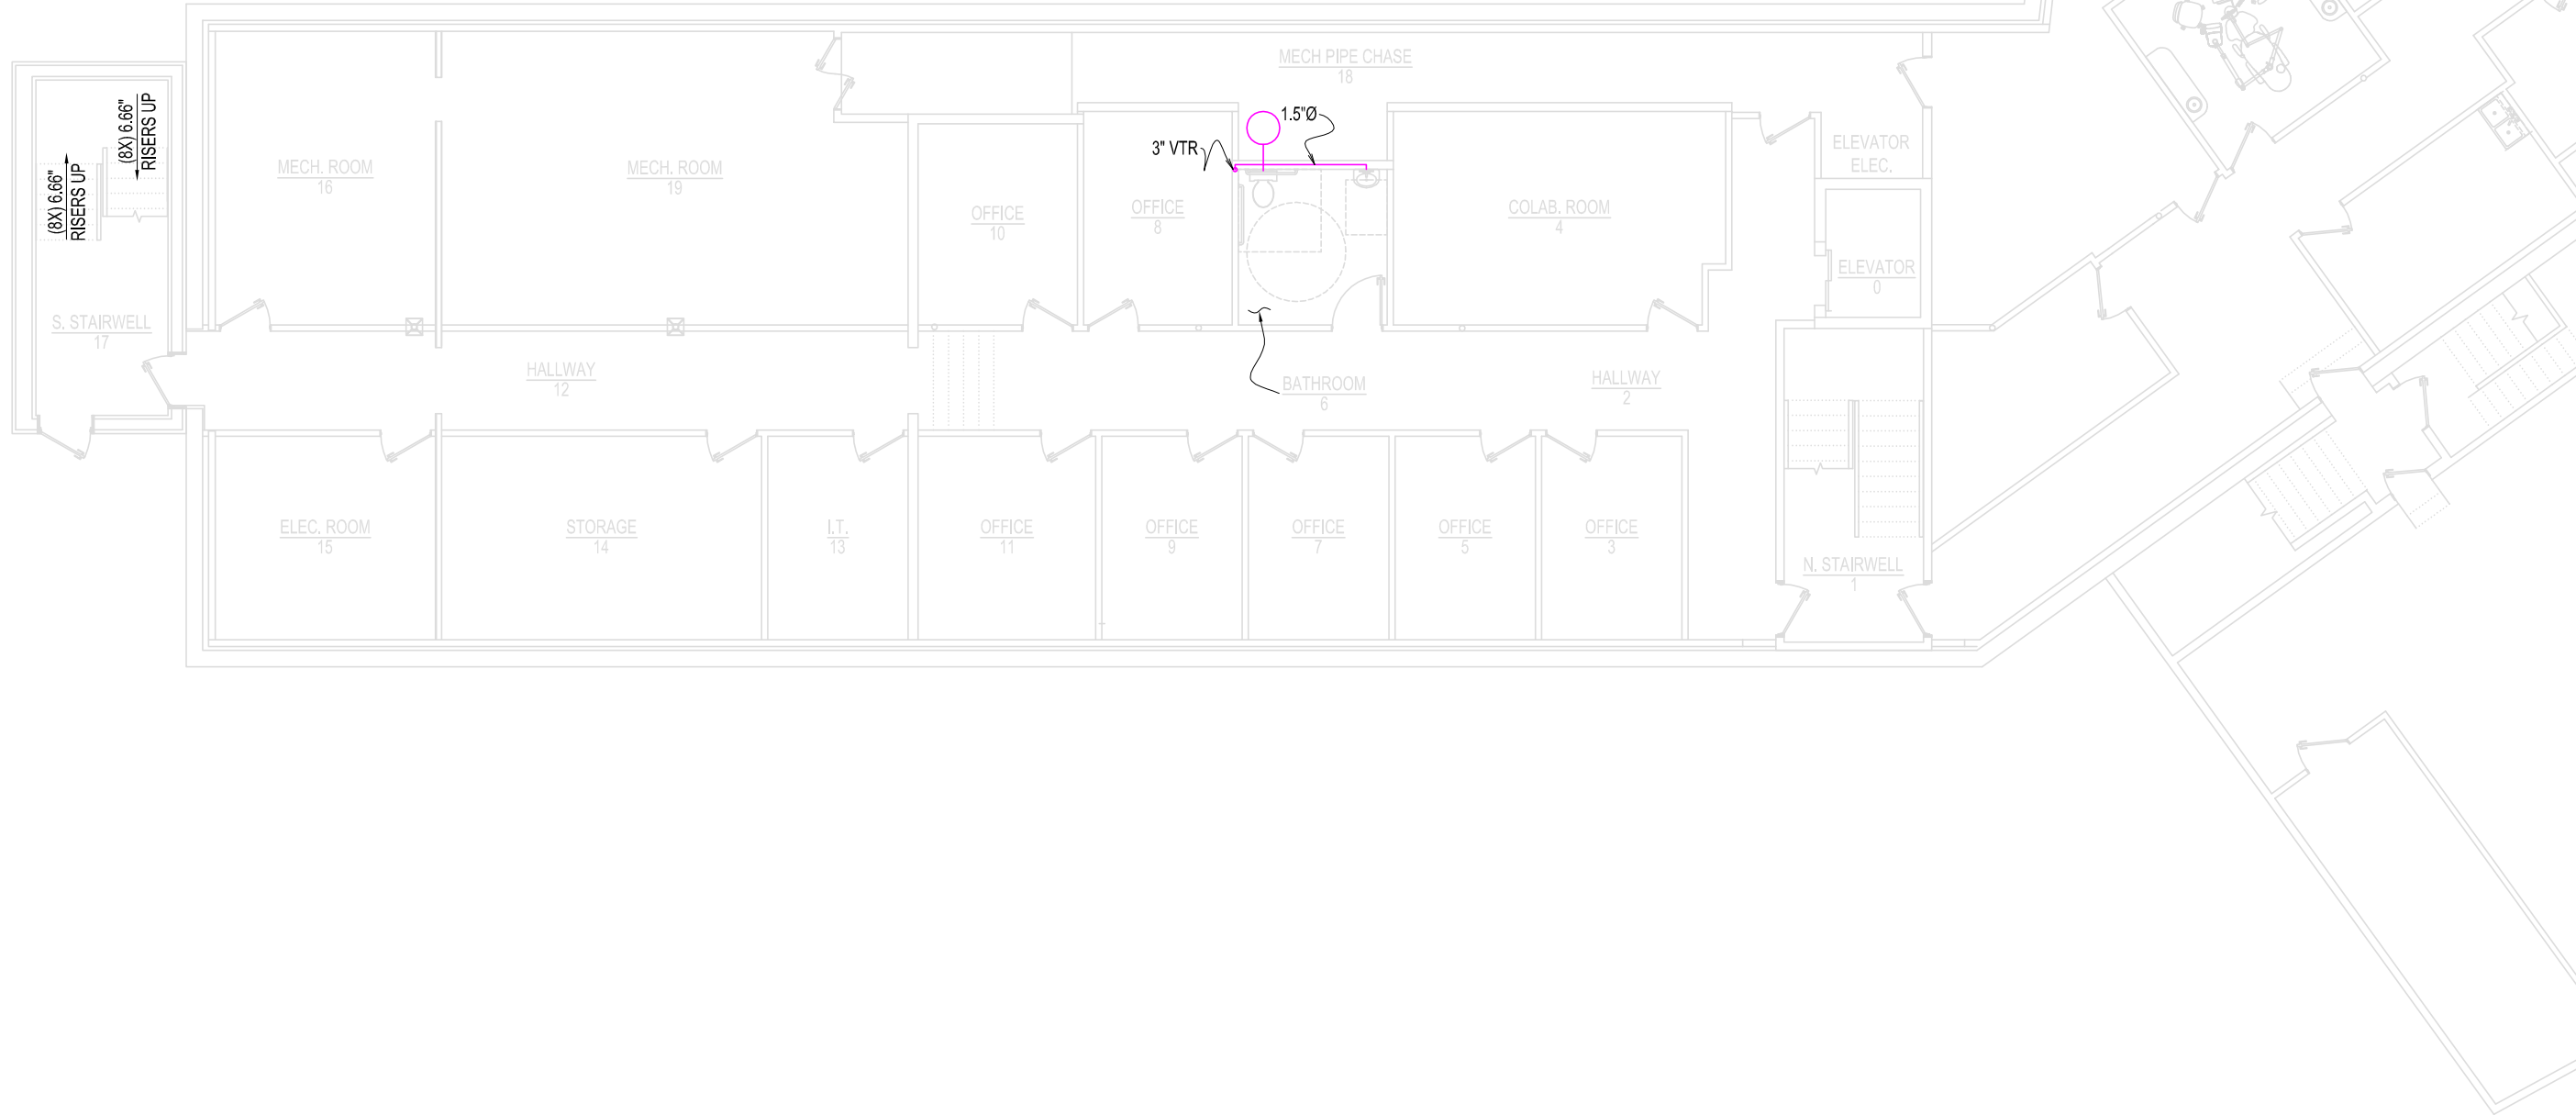

- NOTES:
- 1) ALL HORIZONTAL VENT PIPE 2" DIA.
 - 2) 1.5" V DENOTES VERTICAL 1.5 INCH CONNECTION TO SEPTIC
 - 3) 3" VTR DENOTES 3 INCH VERTICAL-THROUGH-ROOF CONNECTION
 - 4) ALL VENT PIPING SHALL BE SCH 40 PVC DWV PER ASTM D1665
 - 5) INSTALL ALL HORIZONTAL VENT PIPING TO SLOPE TOWARD THE PIPE IT SERVES.

HEALTH CENTER BASEMENT VENTILATION PLAN
SCALE: 3/32 IN. = 1 FT.

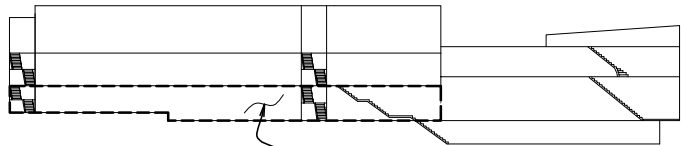

ELEVATION KEY

FOR CONSTRUCTION
REV 0/08



HEALTH CENTER BASEMENT VENTILATION PLAN

ST. CROIX HEALTH CENTER
MAIN STREET
CALAIS, MAINE

DATE: 09/22/26
SCALE: NOTED
DRAWN: LW
JOB NO: 26001P
P12

THIS DRAWING IS AN INSTRUMENT
DESIGNED TO FACILITATE THE WORK
UNDER THE JOB NUMBER INDICATED.
IT IS THE PROPERTY OF FORESIGHT
ENGINEERING AND IS NOT TO BE USED
FOR OTHER WORK ACCEPT BY
WRITTEN AGREEMENT WITH
FORESIGHT ENGINEERING.

FORESIGHT ENGINEERING P.C.
10 FLEMING STREET
LINCOLN, MAINE 04457
(207) 794-2775
(PHONE OR FAX)

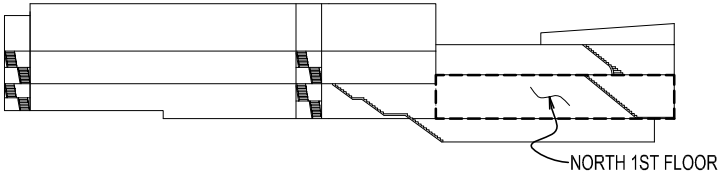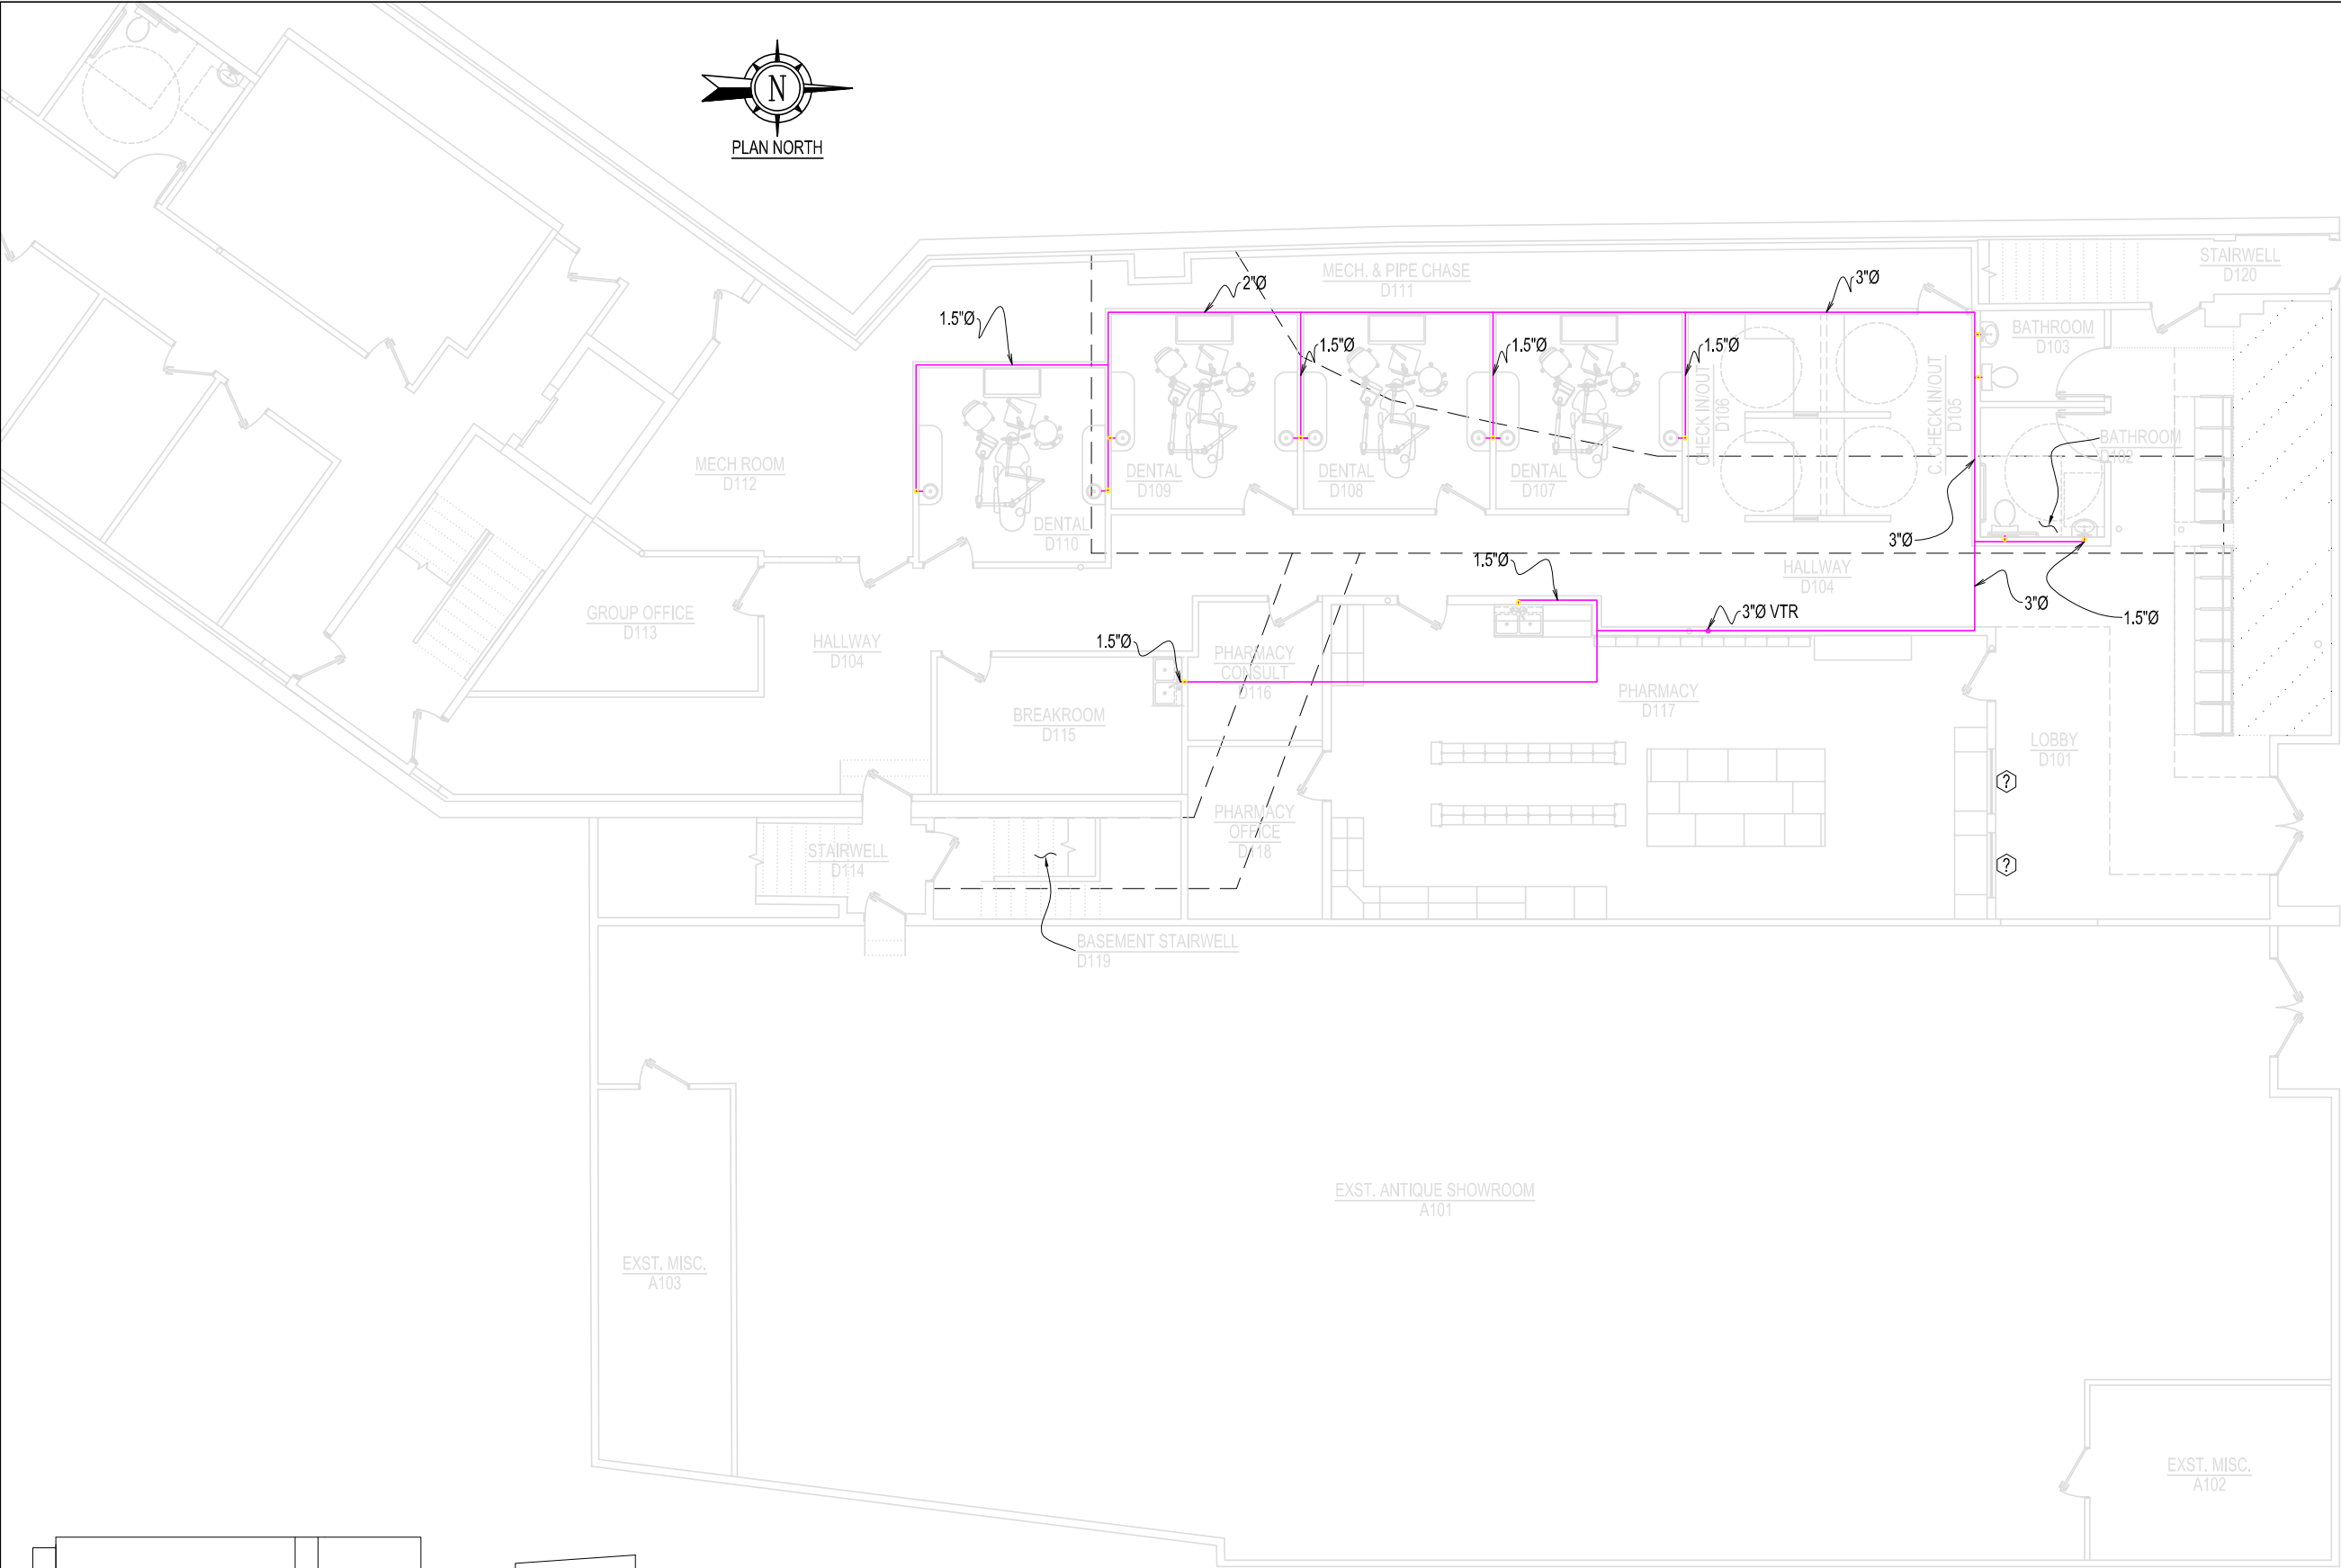

ELEVATION KEY

DENTAL 1ST FLOOR VENTILATION PLAN
SCALE: 3/32 IN. = 1 FT.

FOR CONSTRUCTION
REV 0/08

FORESIGHT ENGINEERING P.C.

10 FLEMING STREET
LINCOLN, MAINE 04457
(207) 794-2775
(PHONE OR FAX)


THIS DRAWING IS AN INSTRUMENT
DESIGNED TO FACILITATE THE WORK
UNDER THE JOB NUMBER INDICATED.
IT IS THE PROPERTY OF FORESIGHT
ENGINEERING AND IS NOT TO BE USED
FOR OTHER WORK ACCEPT BY
WRITTEN AGREEMENT WITH
FORESIGHT ENGINEERING.

DENTAL 1ST FLOOR VENTILATION PLAN

ST. CROIX HEALTH CENTER
MAIN STREET
CALAIS, MAINE


DATE: 09/22/26
SCALE: NOTED
DRAWN: LW

JOB NO: 26001P
P13

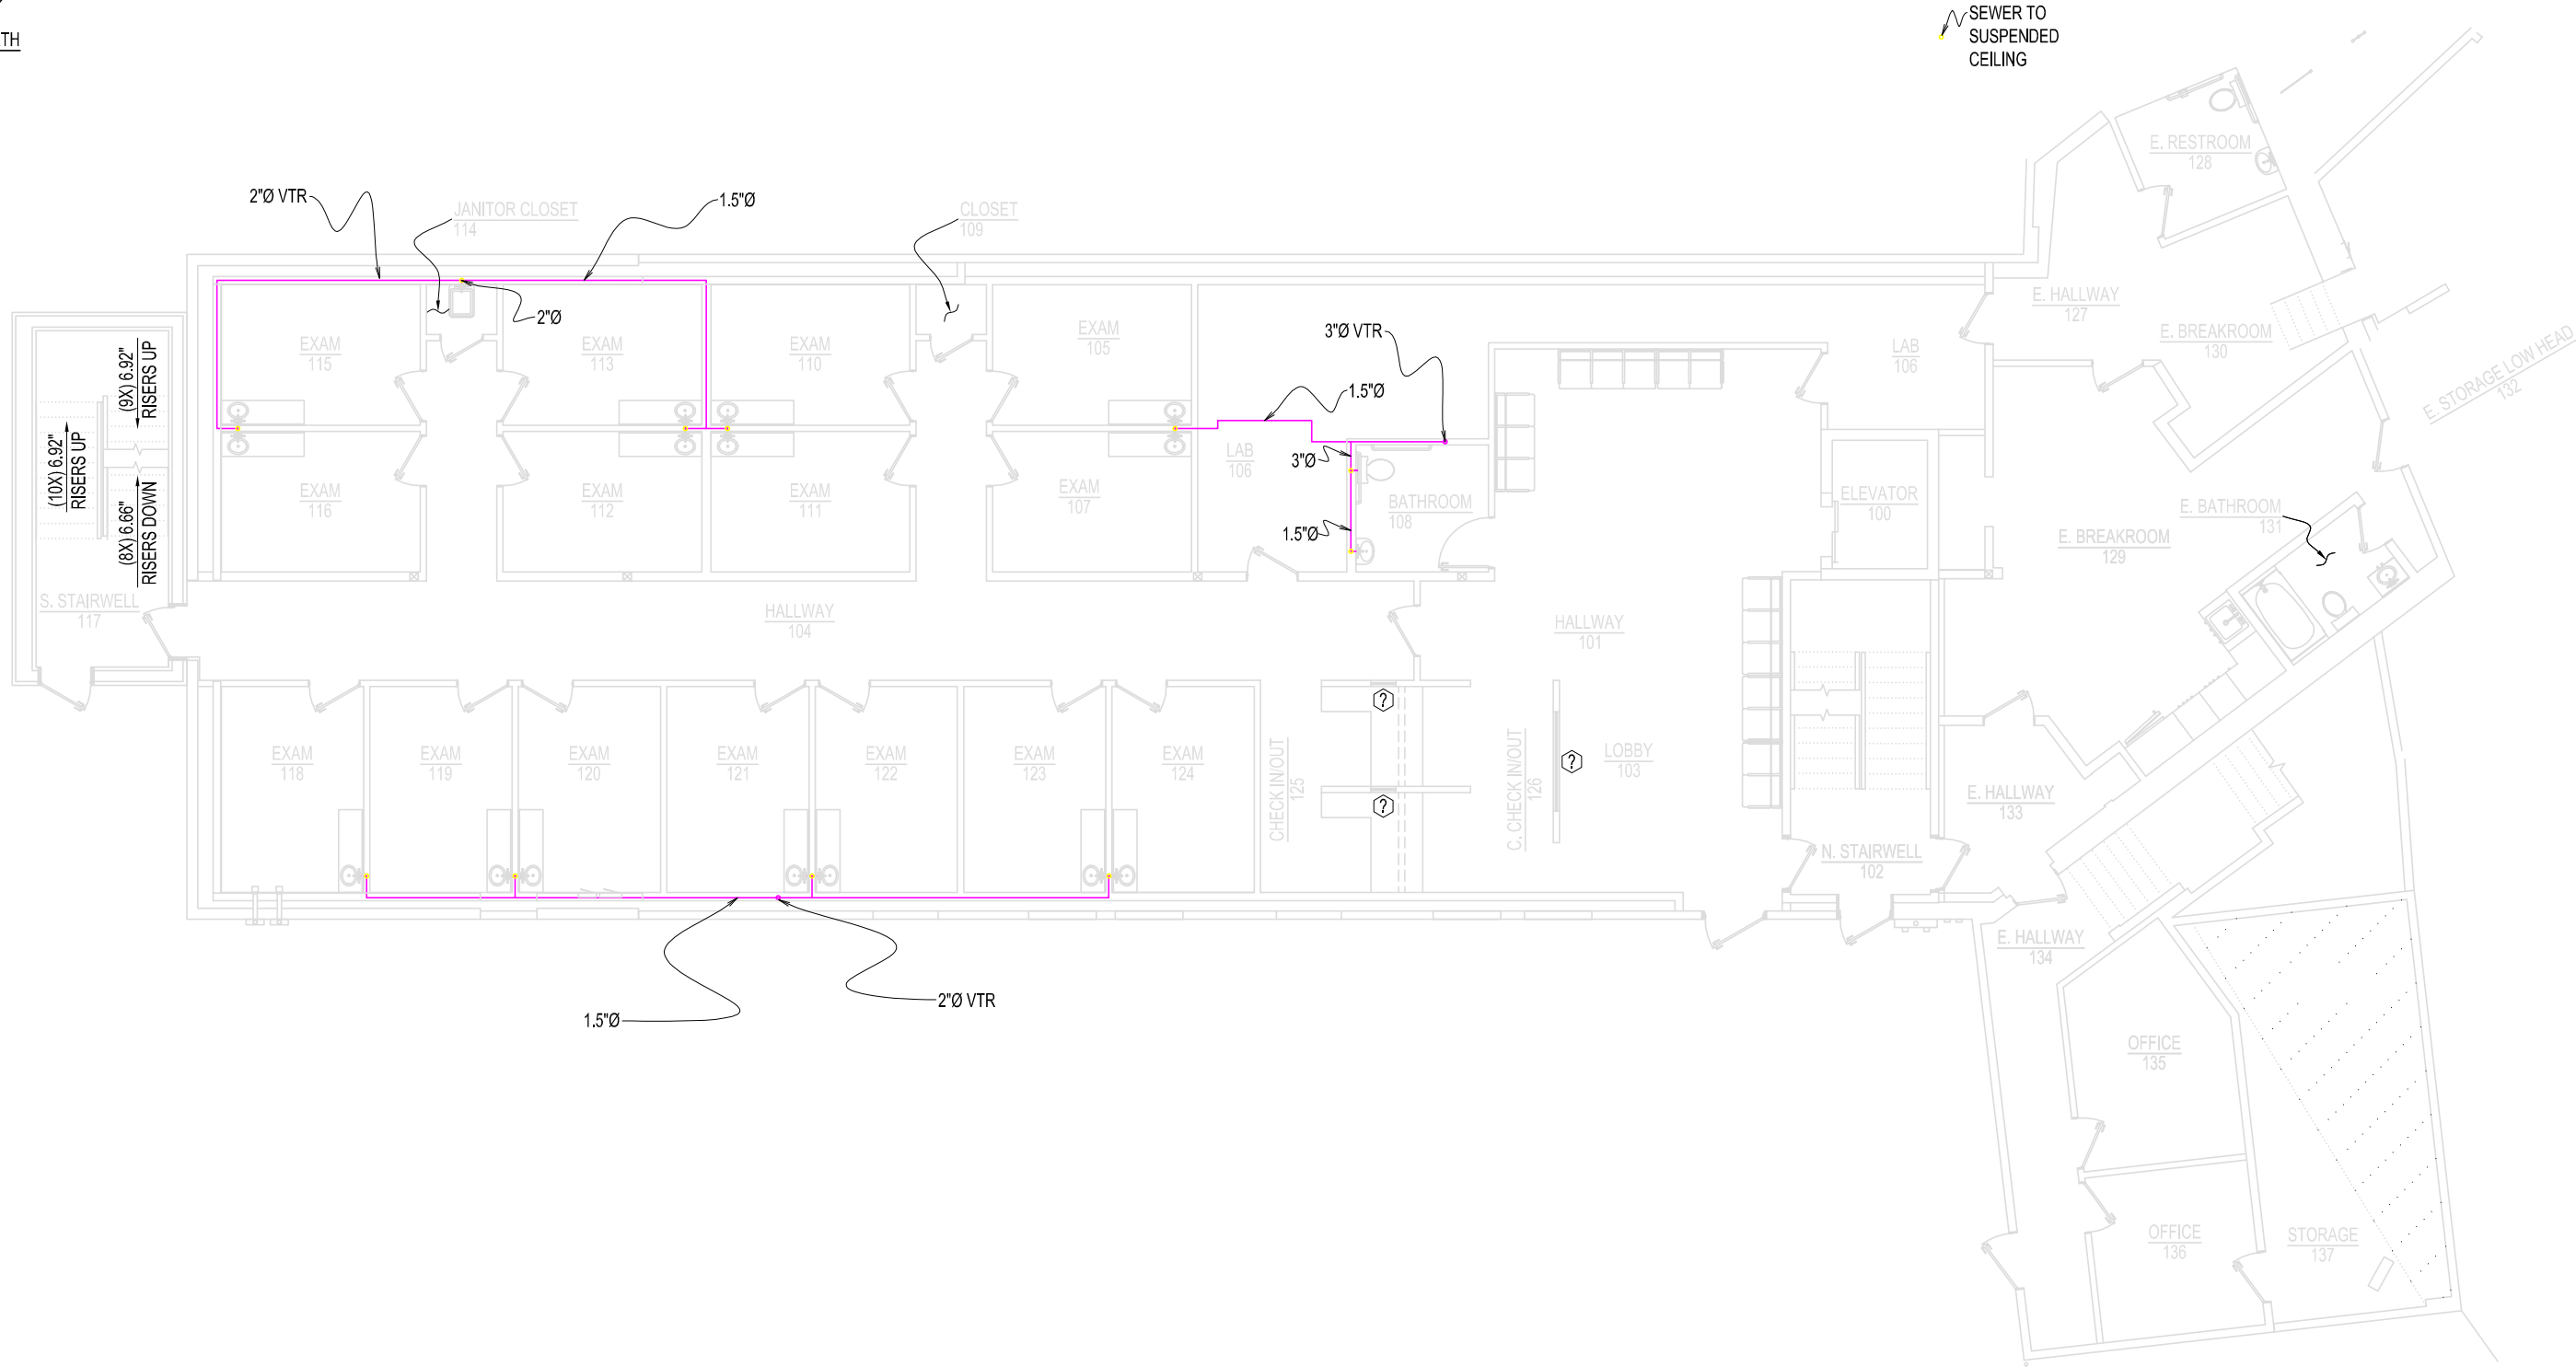

- NOTES:
- 1) ALL HORIZONTAL VENT PIPE 2" DIA.
 - 2) 1.5" V DENOTES VERTICAL 1.5 INCH CONNECTION TO SEPTIC
 - 3) 3" VTR DENOTES 3 INCH VERTICAL-THROUGH-ROOF CONNECTION
 - 4) ALL VENT PIPING SHALL BE SCH 40 PVC DWV PER ASTM D1665
 - 5) INSTALL ALL HORIZONTAL VENT PIPING TO SLOPE TOWARD THE PIPE IT SERVES.

HEALTH CENTER 1ST FLOOR VENTILATION PLAN
SCALE: 3/32 IN. = 1 FT.

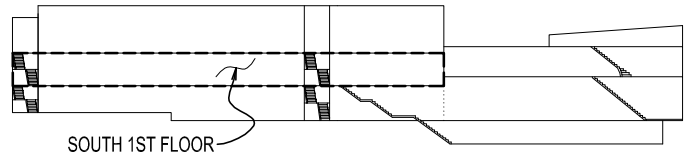

ELEVATION KEY


FOR CONSTRUCTION
REV 0/08

FORESIGHT ENGINEERING P.C.
10 FLEMING STREET
LINCOLN, MAINE 04457
(207) 794-2775
(PHONE OR FAX)

THIS DRAWING IS AN INSTRUMENT
DESIGNED TO FACILITATE THE WORK
UNDER THE JOB NUMBER INDICATED.
IT IS THE PROPERTY OF FORESIGHT
ENGINEERING AND IS NOT TO BE USED
FOR OTHER WORK ACCEPT BY
WRITTEN AGREEMENT WITH
FORESIGHT ENGINEERING.

HEALTH CENTER 1ST FLOOR VENTILATION PLAN
ST. CROIX HEALTH CENTER
MAIN STREET
CALAIS, MAINE

DATE: 09/22/26
SCALE: NOTED
DRAWN: LW
JOB NO: 26001P
P14

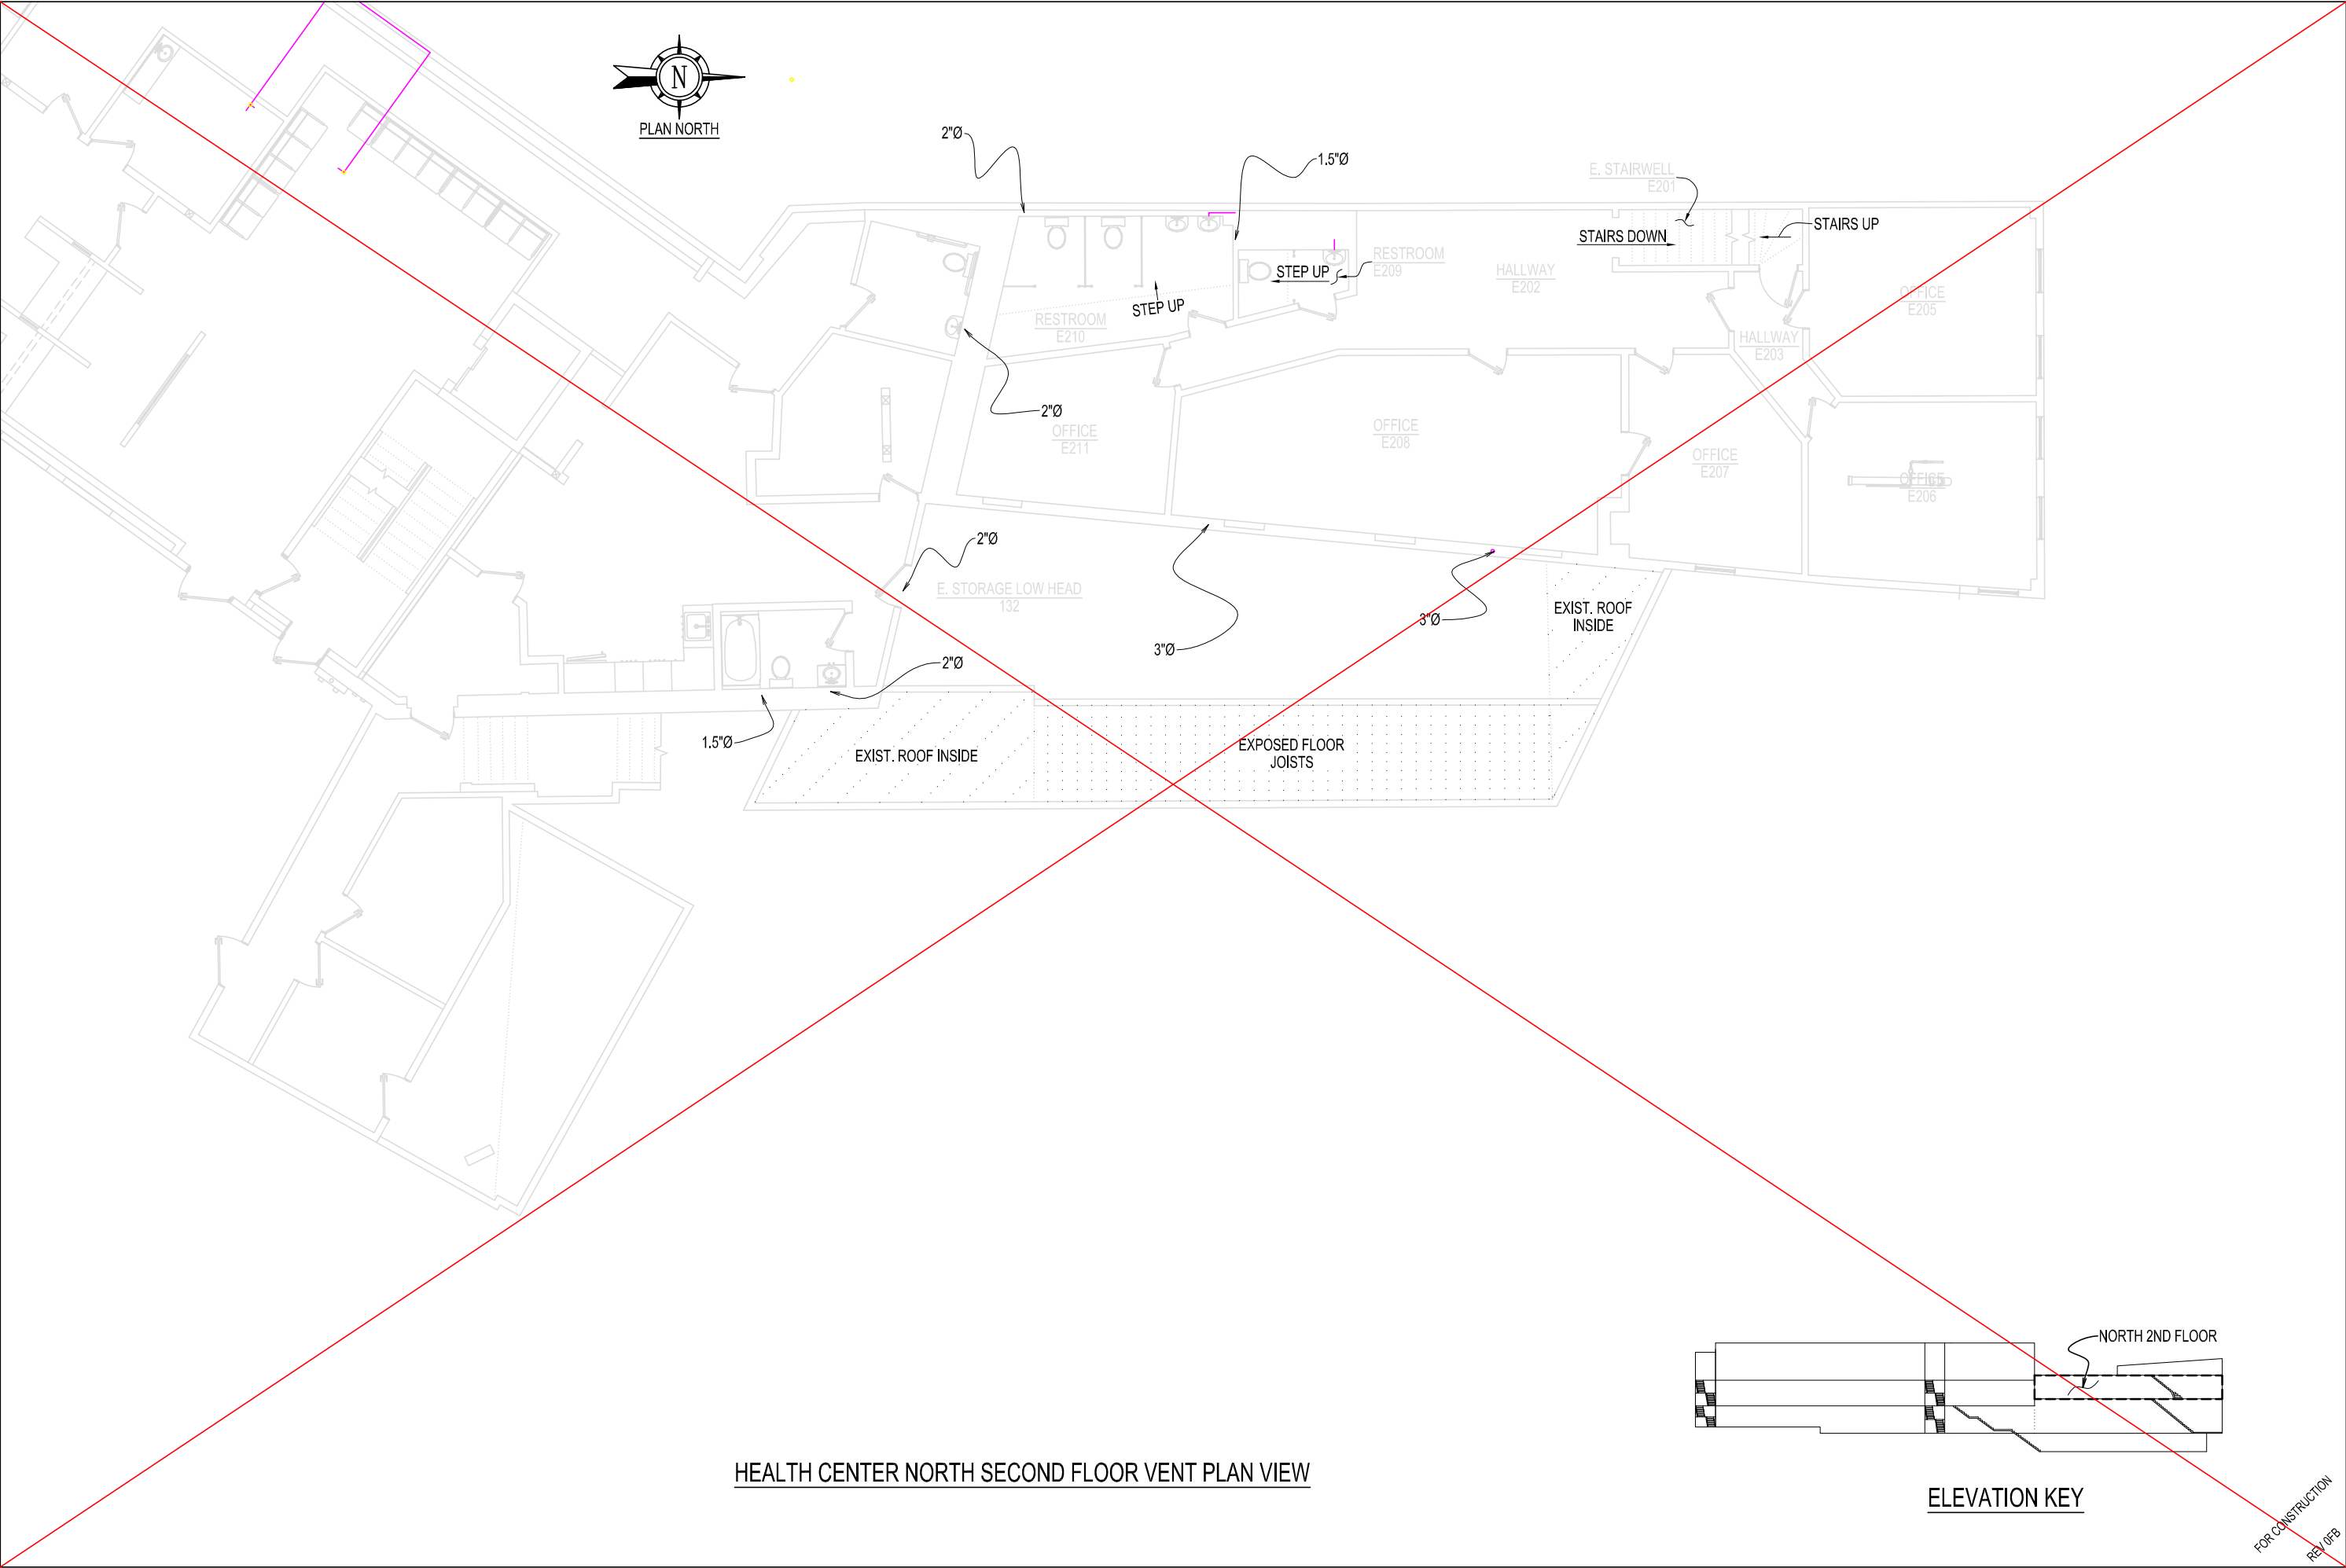

FORESIGHT ENGINEERING P.C.

10 FLEMING STREET
LINCOLN, MAINE 04457
(207) 794-2775
(PHONE OR FAX)

THIS DRAWING IS AN INSTRUMENT
DESIGNED TO FACILITATE THE WORK
UNDER THE JOB NUMBER INDICATED.
IT IS THE PROPERTY OF FORESIGHT
ENGINEERING AND IS NOT TO BE USED
FOR OTHER WORK ACCEPT BY
WRITTEN AGREEMENT WITH
FORESIGHT ENGINEERING.


GENERAL NOTES & INDEX

ST. CROIX HEALTH CENTER
MAIN STREET
CALAIS, MAINE

DATE: 09/22/26
SCALE: NOTED
DRAWN: LW


JOB NO: 26001P
P15

FOR CONSTRUCTION
REV 0/FB

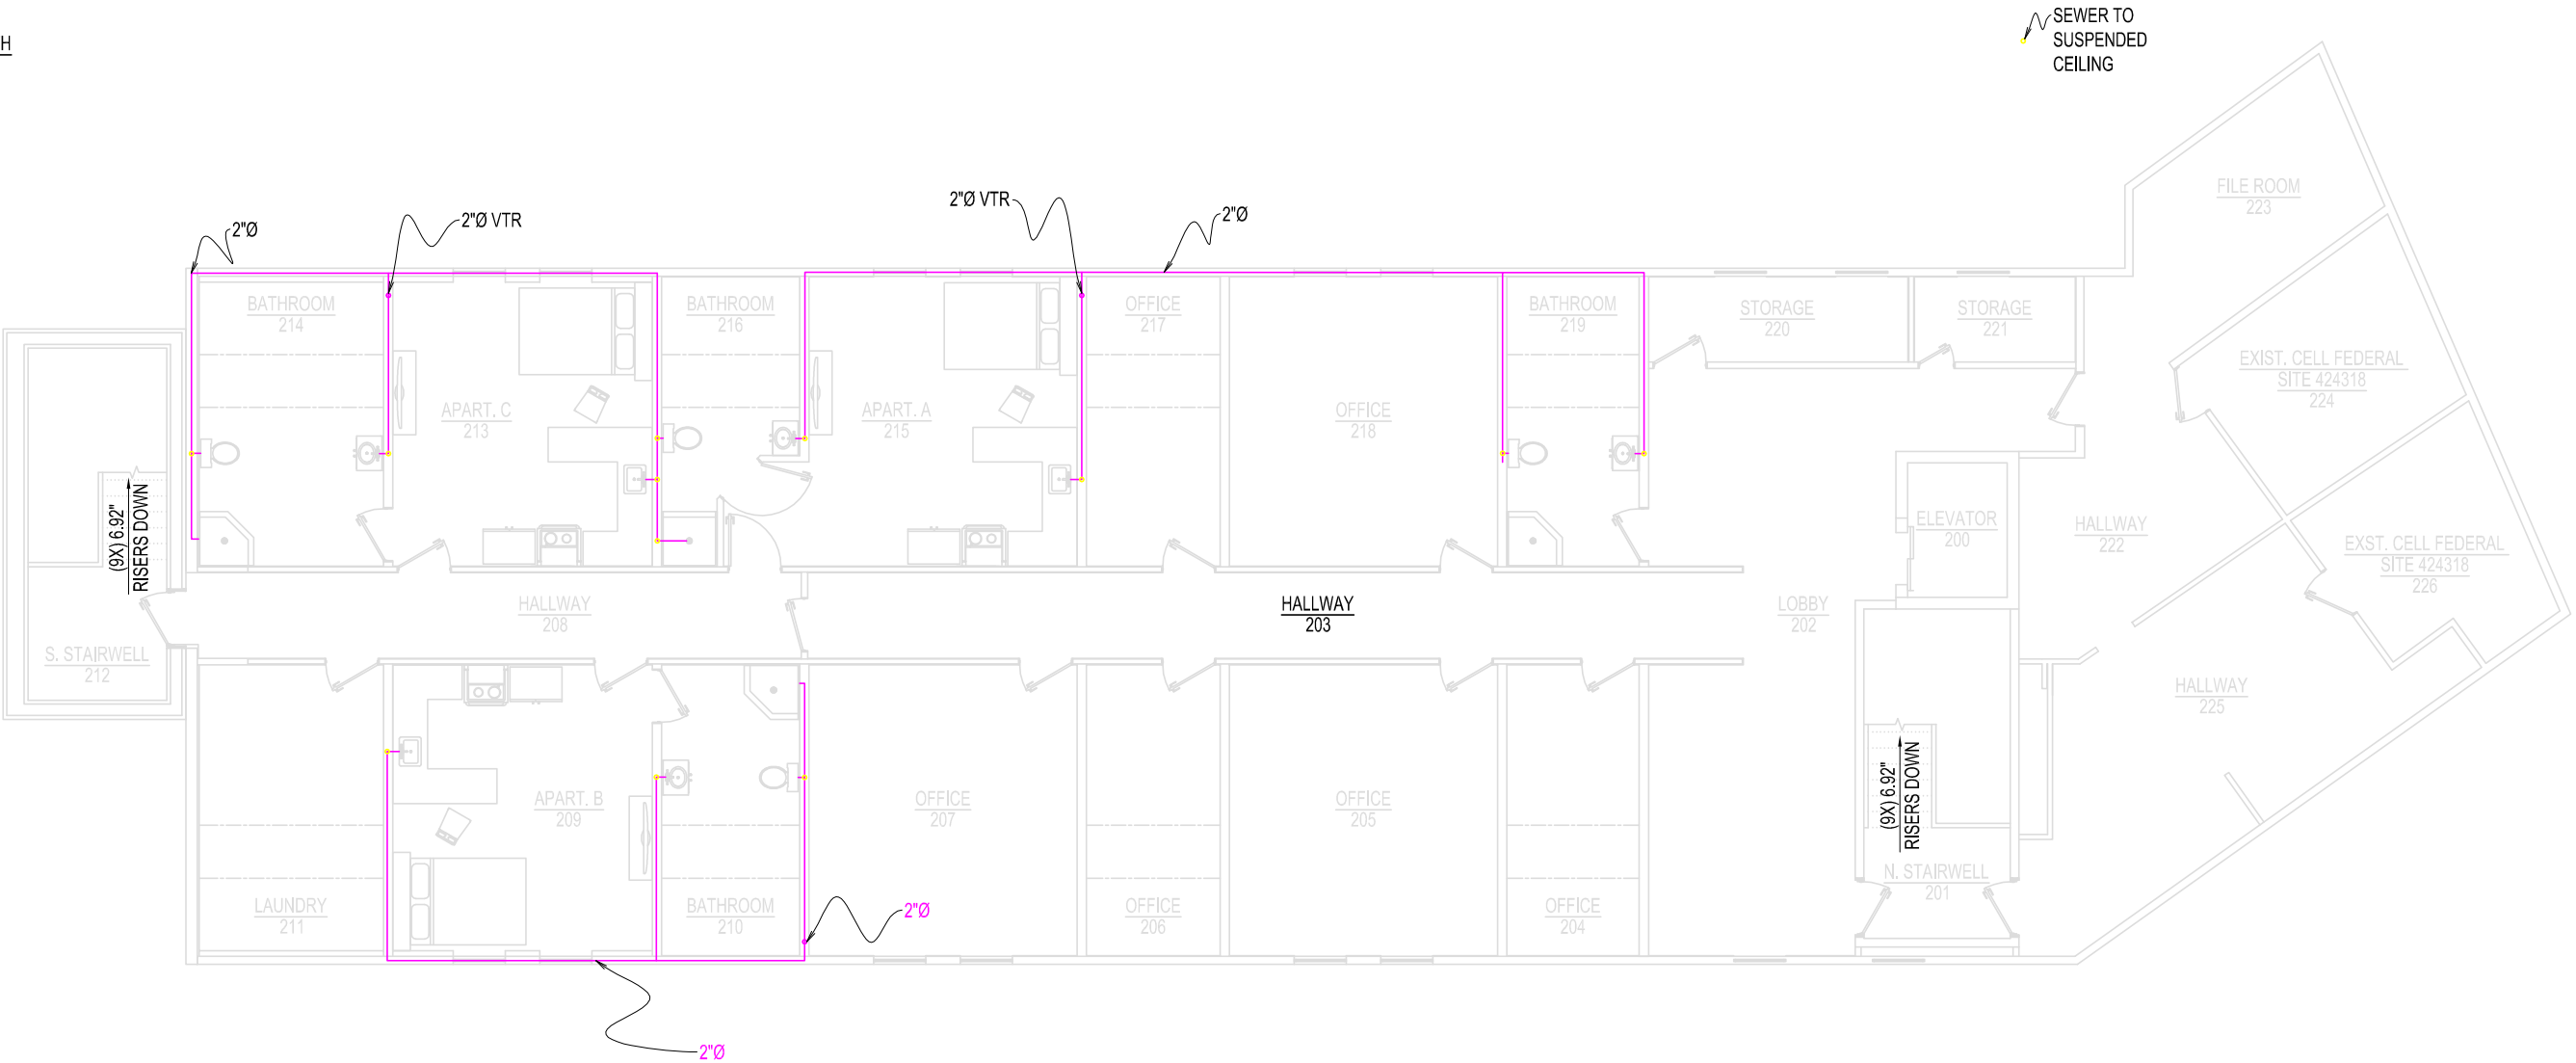

- NOTES:
- 1) ALL HORIZONTAL VENT PIPE 2" DIA.
 - 2) 1.5" V DENOTES VERTICAL 1.5 INCH CONNECTION TO SEPTIC
 - 3) 3" VTR DENOTES 3 INCH VERTICAL-THROUGH-ROOF CONNECTION
 - 4) ALL VENT PIPING SHALL BE SCH 40 PVC DWV PER ASTM D1665
 - 5) INSTALL ALL HORIZONTAL VENT PIPING TO SLOPE TOWARD THE PIPE IT SERVES.

APARTMENTS 2ND FLOOR VENTILATION PLAN
SCALE: 3/32 IN. = 1 FT.

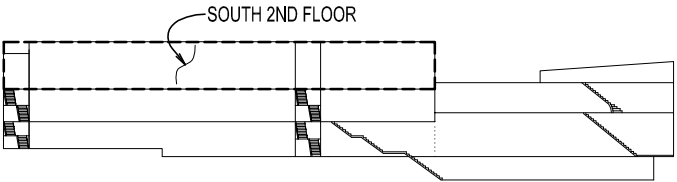

ELEVATION KEY

FOR CONSTRUCTION
REV 0/08

FORESIGHT ENGINEERING P.C.
10 FLEMING STREET
LINCOLN, MAINE 04457
(207) 794-2775
(PHONE OR FAX)

THIS DRAWING IS AN INSTRUMENT
DESIGNED TO FACILITATE THE WORK
UNDER THE JOB NUMBER INDICATED.
IT IS THE PROPERTY OF FORESIGHT
ENGINEERING AND IS NOT TO BE USED
FOR OTHER WORK ACCEPT BY
WRITTEN AGREEMENT WITH
FORESIGHT ENGINEERING.

APARTMENTS 2ND FLOOR VENTILATION PLAN

ST. CROIX HEALTH CENTER
MAIN STREET
CALAIS, MAINE

DATE: 09/22/26
SCALE: NOTED
DRAWN: LW
JOB NO: 26001P
P16

DATE: 09/22/26

SCALE: NOTED

DRAWN: LW

JOB NO: 26001P

SHEET 86

FOR CONSTRUCTION

REV 0/08

GENERAL NOTES & INDEX

ST. CROIX HEALTH CENTER

MAIN STREET

CALAIS, MAINE

THIS DRAWING IS AN INSTRUMENT
DESIGNED TO FACILITATE THE WORK
UNDER THE JOB NUMBER INDICATED.
IT IS THE PROPERTY OF FORESIGHT
ENGINEERING AND IS NOT TO BE USED
FOR OTHER WORK ACCEPT BY
WRITTEN AGREEMENT WITH
FORESIGHT ENGINEERING.

FORESIGHT ENGINEERING P.C.


10 FLEMING STREET

LINCOLN, MAINE 04457

(207) 794-2775


(PHONE OR FAX)



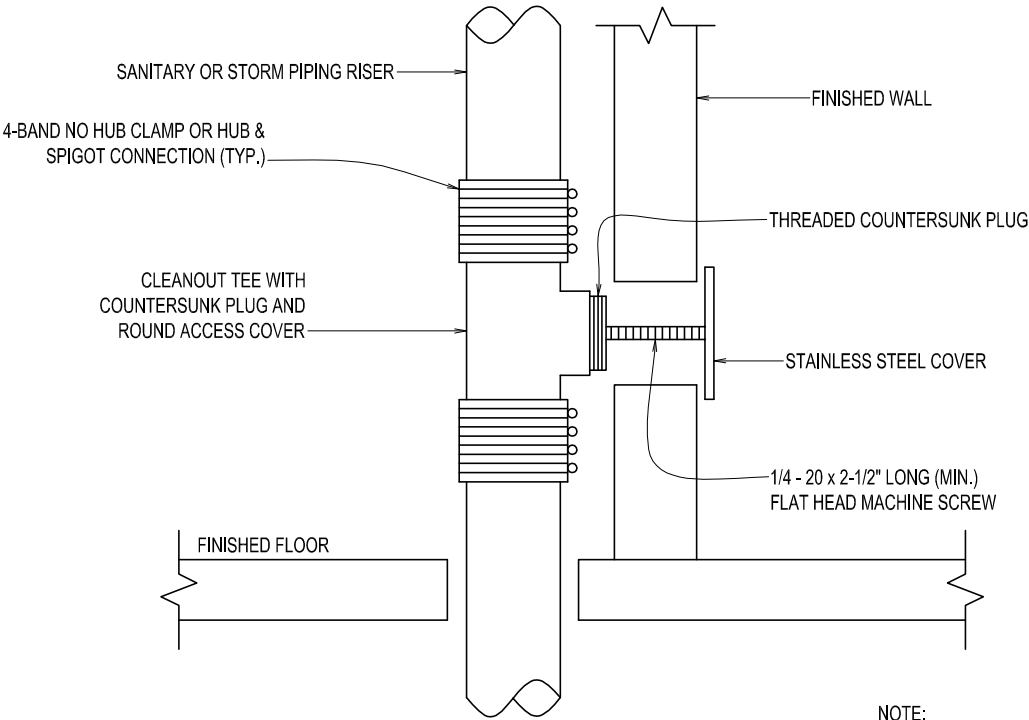


NOTE:
INSTALL FLUSH WALL CLEANOUT
AT THE BASE OF ALL SANITARY
AND STORM PIPING, RISERS.

FLUSH WALL CLEANOUT DETAIL
SCALE: N.T.S.




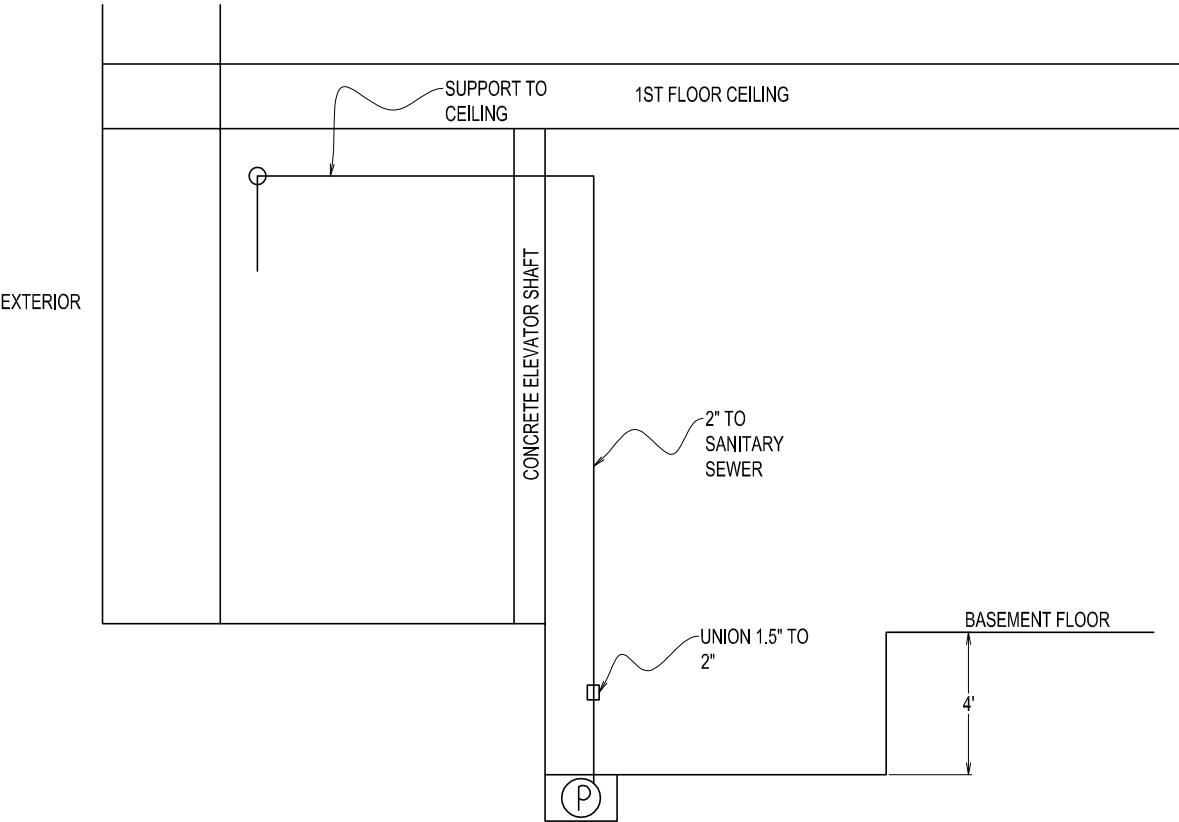


ELEVATOR SUMP PIPING DETAIL
SCALE: N.T.S.

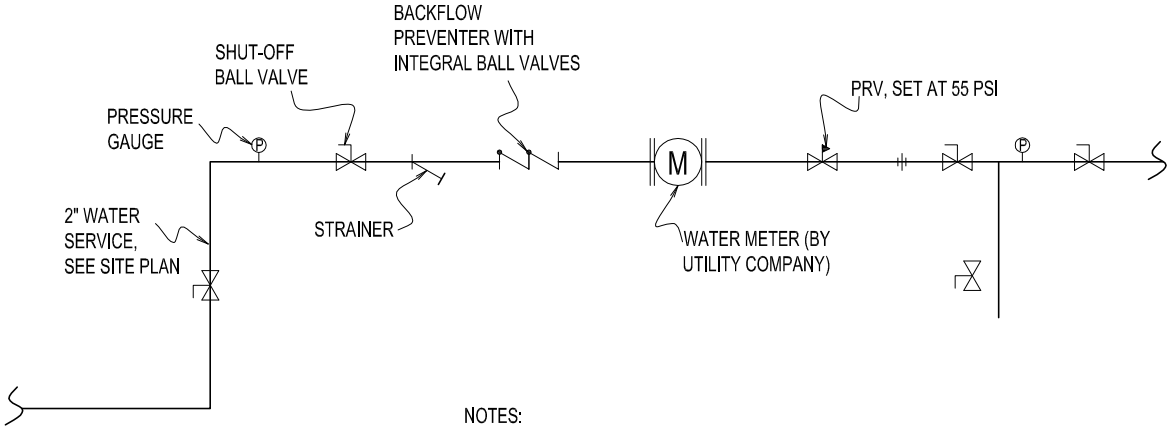

NOTES:
1) MOUNTING HEIGHT : 36" A.F.F.
2) SUPPORT FROM FLOOR WITH MINIMUM (2) PIPE STANDS AT BFP & PRV.
3) MAINTAIN MANUFACTURERS CLEARANCES & LOCAL UTILITY CLEARANCE REQUIREMENTS. NO LESS THAN 36" WORKING SPACE IN FRONT OF ASSEMBLY & NO LESS THAN 12" BEHIND ASSEMBLY.

SERVICE DETAIL
SCALE: N.T.S.

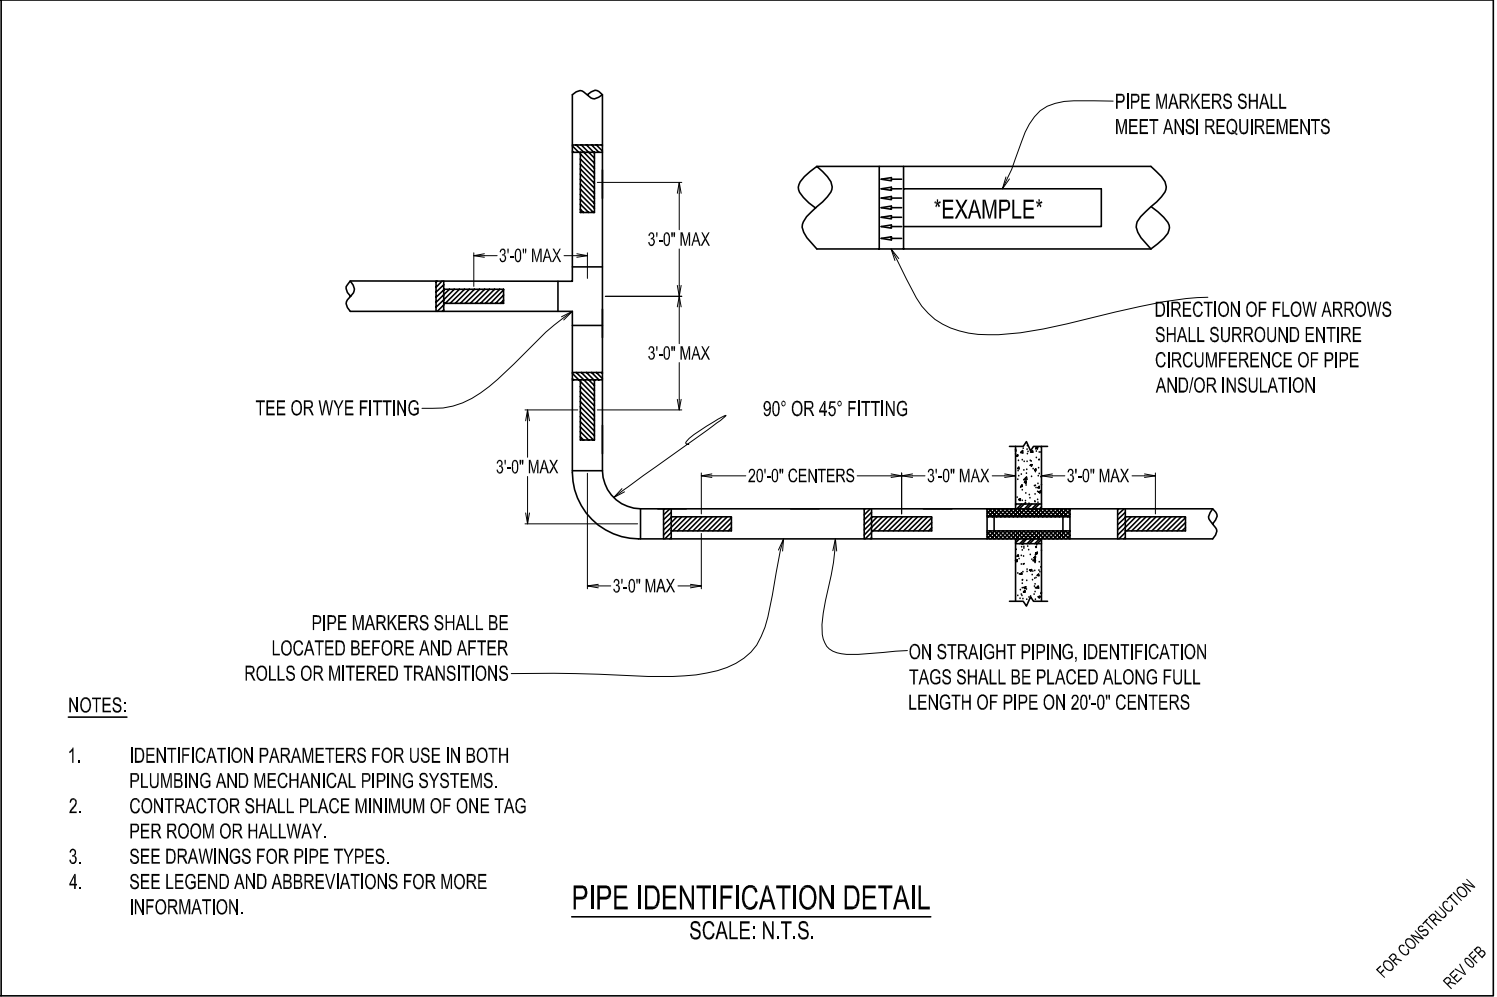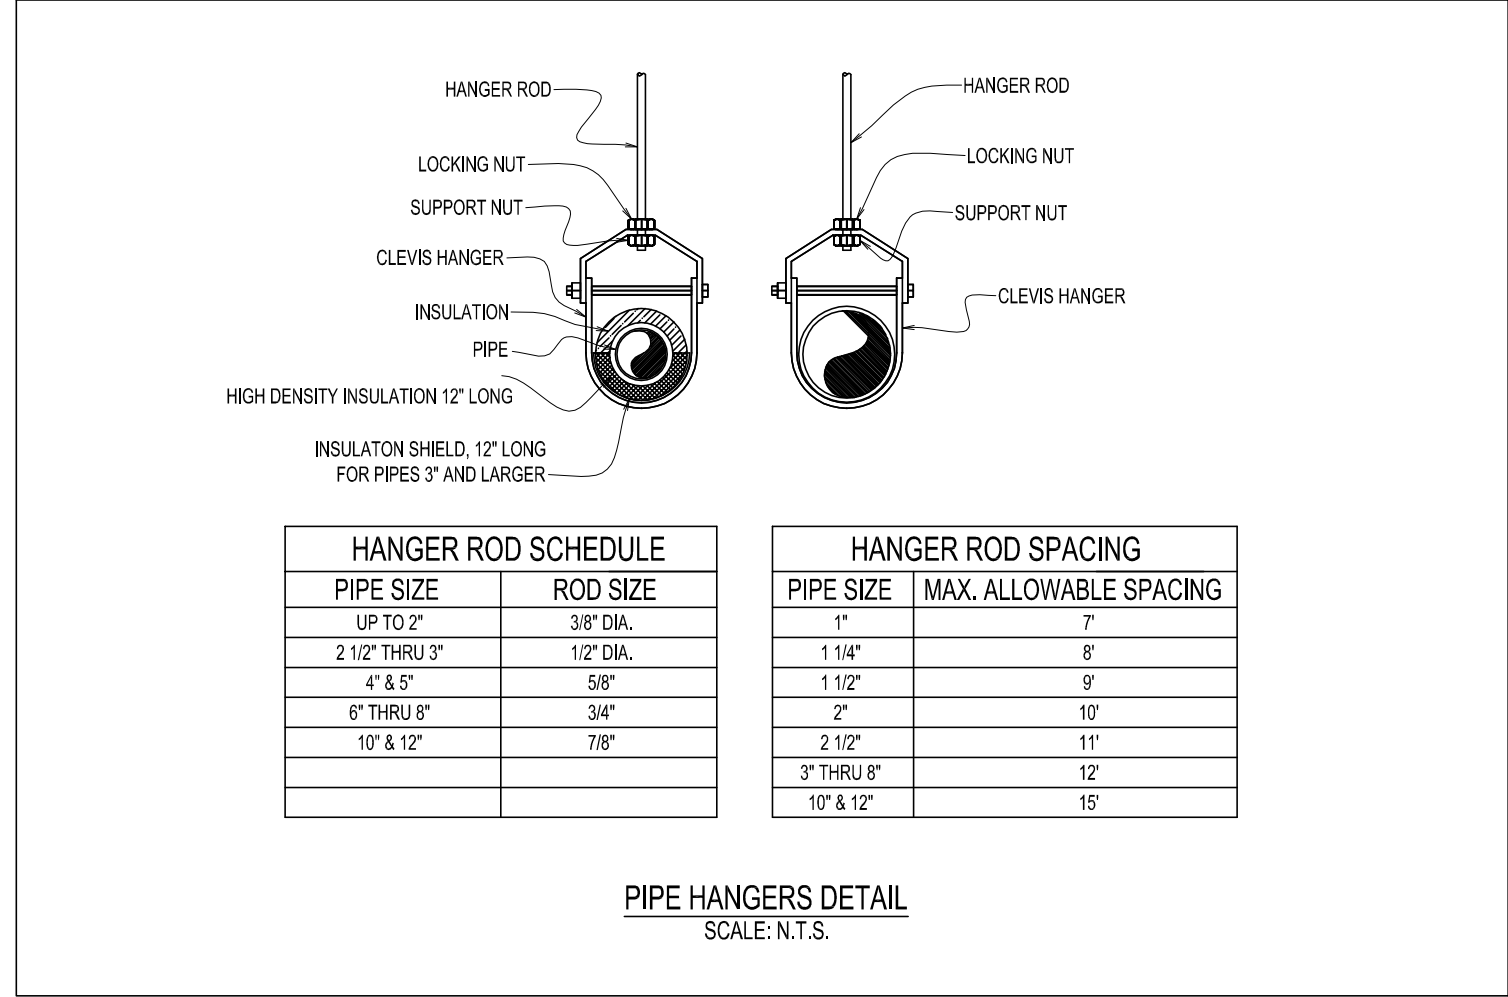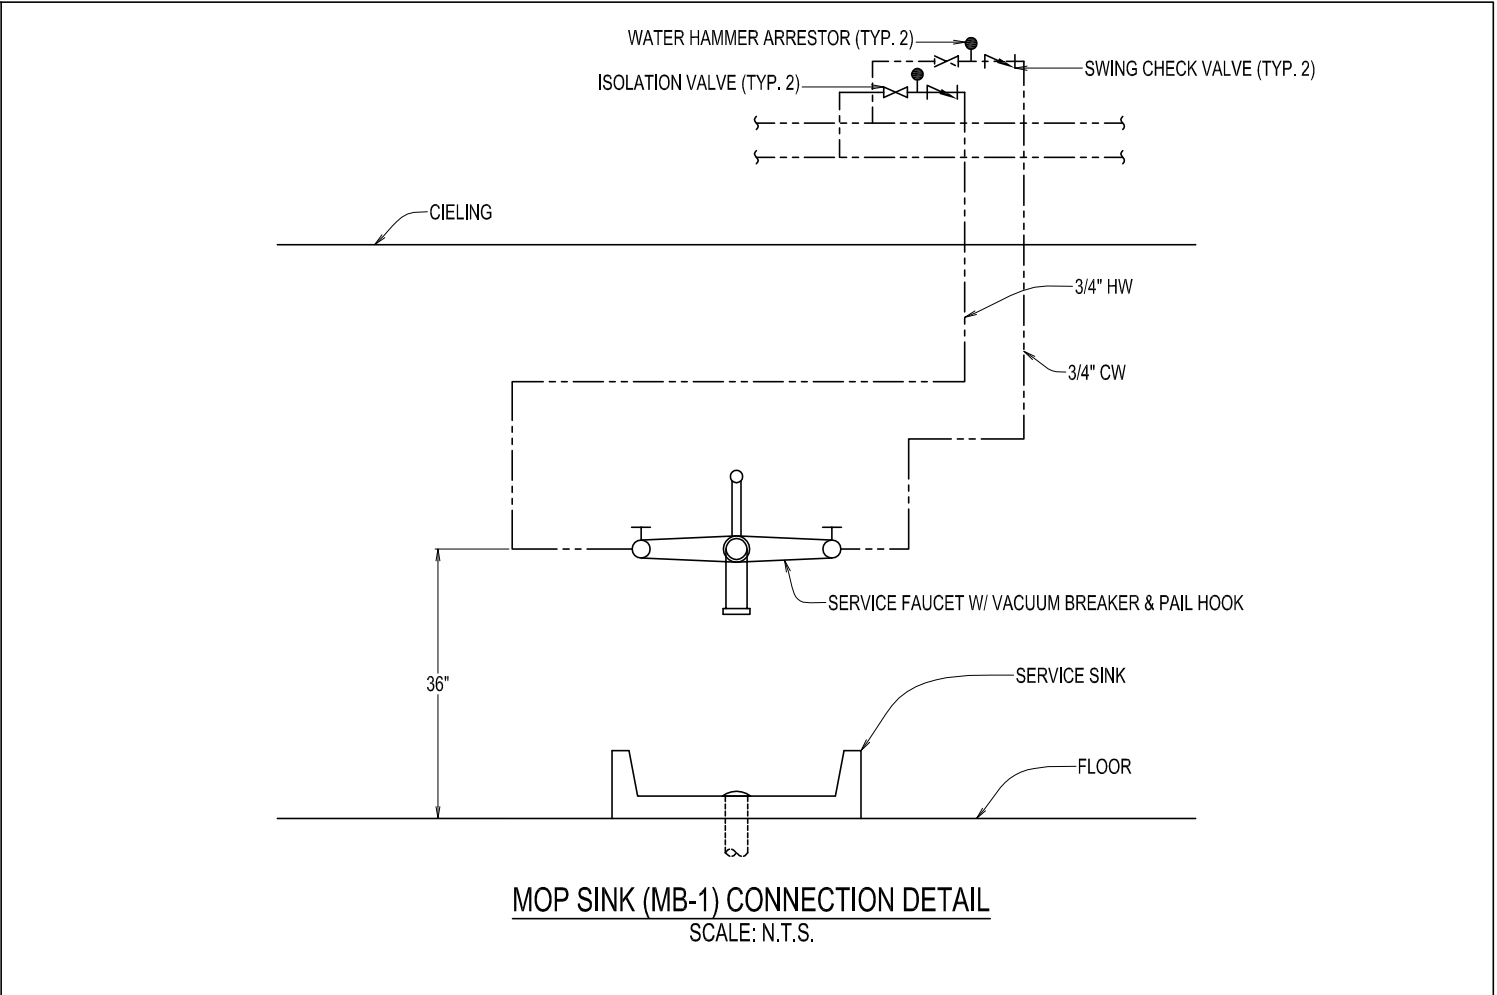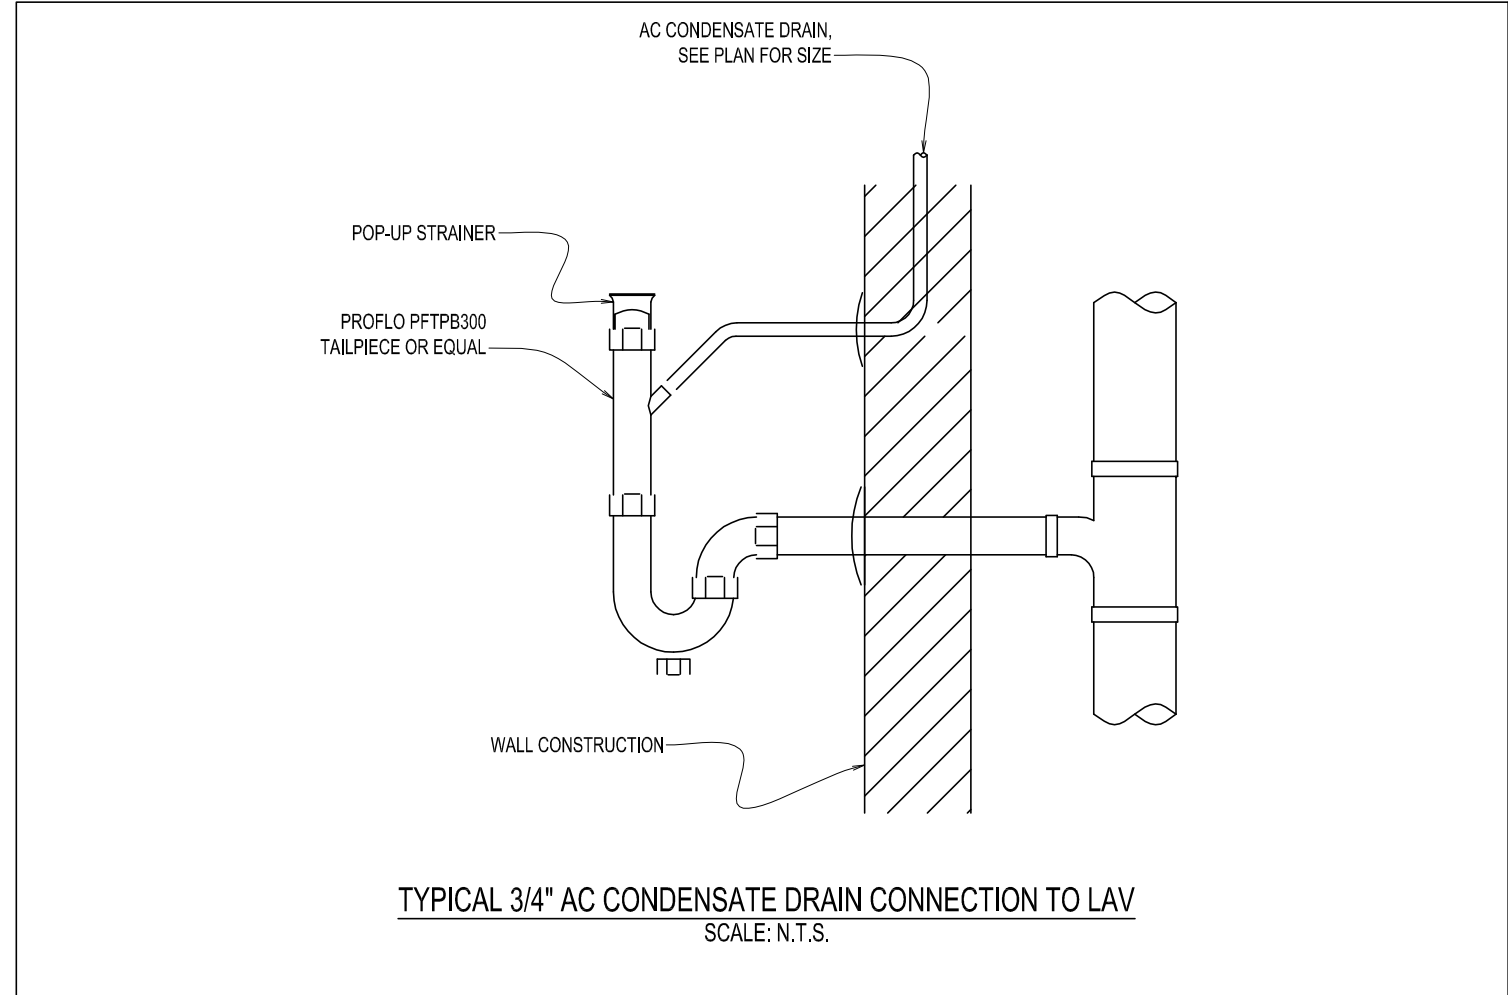

FORESIGHT ENGINEERING P.C.
10 FLEMING STREET
LINCOLN, MAINE 04457
(207) 794-2775
(PHONE OR FAX)

THIS DRAWING IS AN INSTRUMENT
DESIGNED TO FACILITATE THE WORK
UNDER THE JOB NUMBER INDICATED.
IT IS THE PROPERTY OF FORESIGHT
ENGINEERING AND IS NOT TO BE USED
FOR OTHER WORK ACCEPT BY
WRITTEN AGREEMENT WITH
FORESIGHT ENGINEERING.

PLUMBING DETAILS 2 OF 2
ST. CROIX HEALTH CENTER
MAIN STREET
CALAIS, MAINE

DATE: 09/22/26
SCALE: NOTED
DRAWN: LW

JOB NO: 26001P
P19